

THORNE-SAGENDORPH ART GALLERY

Keene State College
Keene, New Hampshire 03431

ARCHITECT

Christopher P. Williams, Architects
P. O. Box 656, 4 Stevens Avenue
Meredith, New Hampshire 03253
(603) 272-3513

CIVIL ENGINEER

H. E. Bergeron Professional Association
P.O. Box 440, Sweet Street
North Conway, New Hampshire 03818
(603) 356-6936

STRUCTURAL ENGINEER

H. E. Bergeron Professional Association
P.O. Box 440, Sweet Street
North Conway, New Hampshire 03818
(603) 356-6936

MECHANICAL ENGINEER

Rist Frost Shumway Engineering P.C.
71 Water Street
Laconia, New Hampshire 03246
(603) 524-4647

ELECTRICAL ENGINEER


Lee F. Carroll, P.E.
P.O. Box 357, Madison Avenue
Gorham, New Hampshire, 03581
(603) 466-5065

SPECIFICATIONS

Steven R. McHugh
22 Packers Falls Road
Newmarket, New Hampshire 03857
(603) 659-7426

LIGHTING CONSULTANT

J & M Associates
P.O. Box 659A
Kennebunkport, Maine 04046
(207) 967-5223

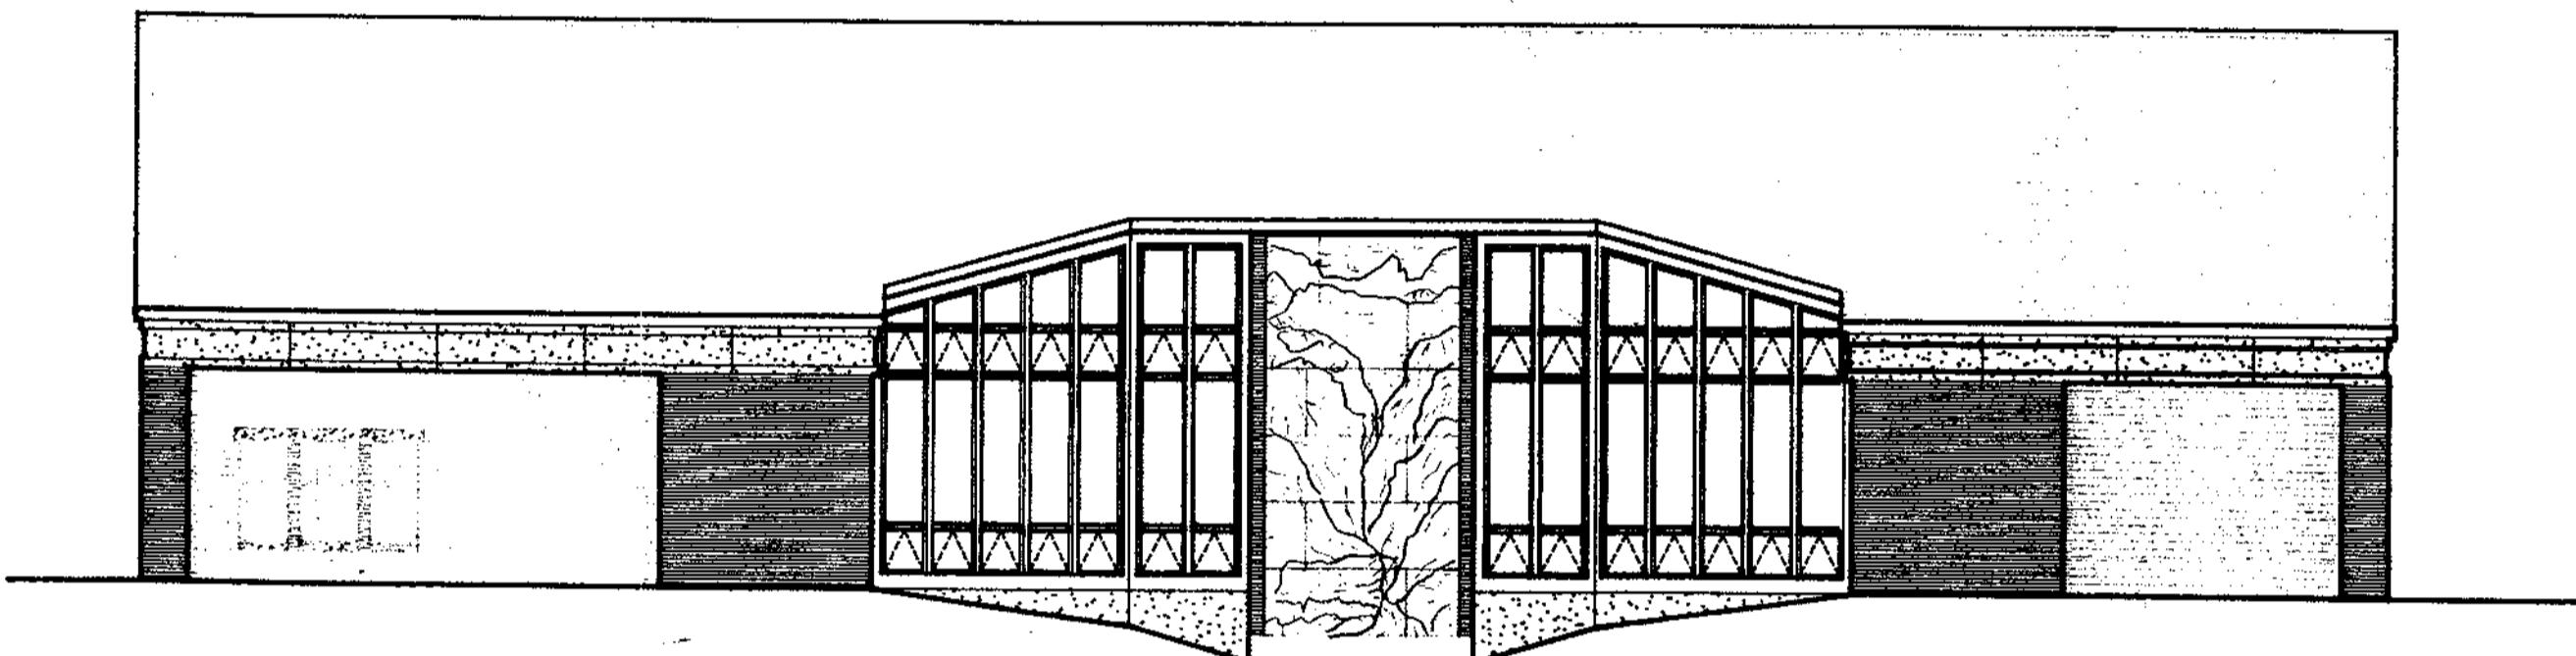

DRAWING INDEX	
	GENERAL
A0	COVER SHEET
	SITE
SP1	SITE PLAN
SP2	CONSTRUCTION DETAILS
SP3	SITE DETAILS
BR1	TEST BORING AND MONITORING WELL LOCATIONS
	ARCHITECTURAL
A1	MAIN LEVEL FLOOR PLAN
A2	UPPER LEVEL FLOOR PLAN
A3	ROOF PLAN
A4	EXTERIOR ELEVATIONS
A5	EXTERIOR ELEVATIONS
A6	BUILDING SECTIONS
A7	BUILDING SECTIONS
A8	BUILDING SECTIONS
A9	WALL SECTIONS
A10	WALL SECTIONS
A11	WALL SECTIONS
A12	STAIRS
A13	PLAN DETAILS
A14	SECTION DETAILS
A15	INTERIOR ELEVATIONS
A16	INTERIOR ELEVATIONS
A17	INTERIOR ELEVATIONS
A18	DOOR AND HARDWARE SCHEDULE
A19	WINDOW AND FINISH SCHEDULE
A20	REFLECTED CEILING PLAN
A21	MISC. DETAILS
A22	MILLWORK
	STRUCTURAL
S1	FOUNDATION PLAN
S2	UPPER LEVEL FRAMING PLAN
S3	ROOF FRAMING PLAN
S4	STRUCTURAL DETAILS
	MECHANICAL
M1	GEN. NOTES, LEGEND & SCHEDULES
M2	MAIN LEVEL DUCTWORK & PIPING
M3	UPPER LEVEL DUCTWORK
M4	MECHANICAL ROOM PLANS
M5	DETAILS
M6	SCHEDULES
	PLUMBING
P1	GEN. NOTES, SCHEDULES & RISERS
P2	PLUMBING PLANS, SECTS & DETAILS
	ELECTRICAL
E1	MAIN LEVEL POWER
E2	MAIN LEVEL LIGHTING
E3	UPPER LEVEL POWER
E4	UPPER LEVEL LIGHTING
	APPENDIX
S1	SURCHARGE PLAN
S2	SURCHARGE SECTIONS



Copyright 1992
C.P. Williams
All Rights Reserved

THORNE-SAGENDORPH
ART GALLERY
Keene State College
Keene, New Hampshire


COVER SHEET


DATE: 1 SEPTEMBER 1992
SCALE: AS SHOWN
DRW BY: RGH
PROJ. NO.: GO3
A0
GO3CVR

#3

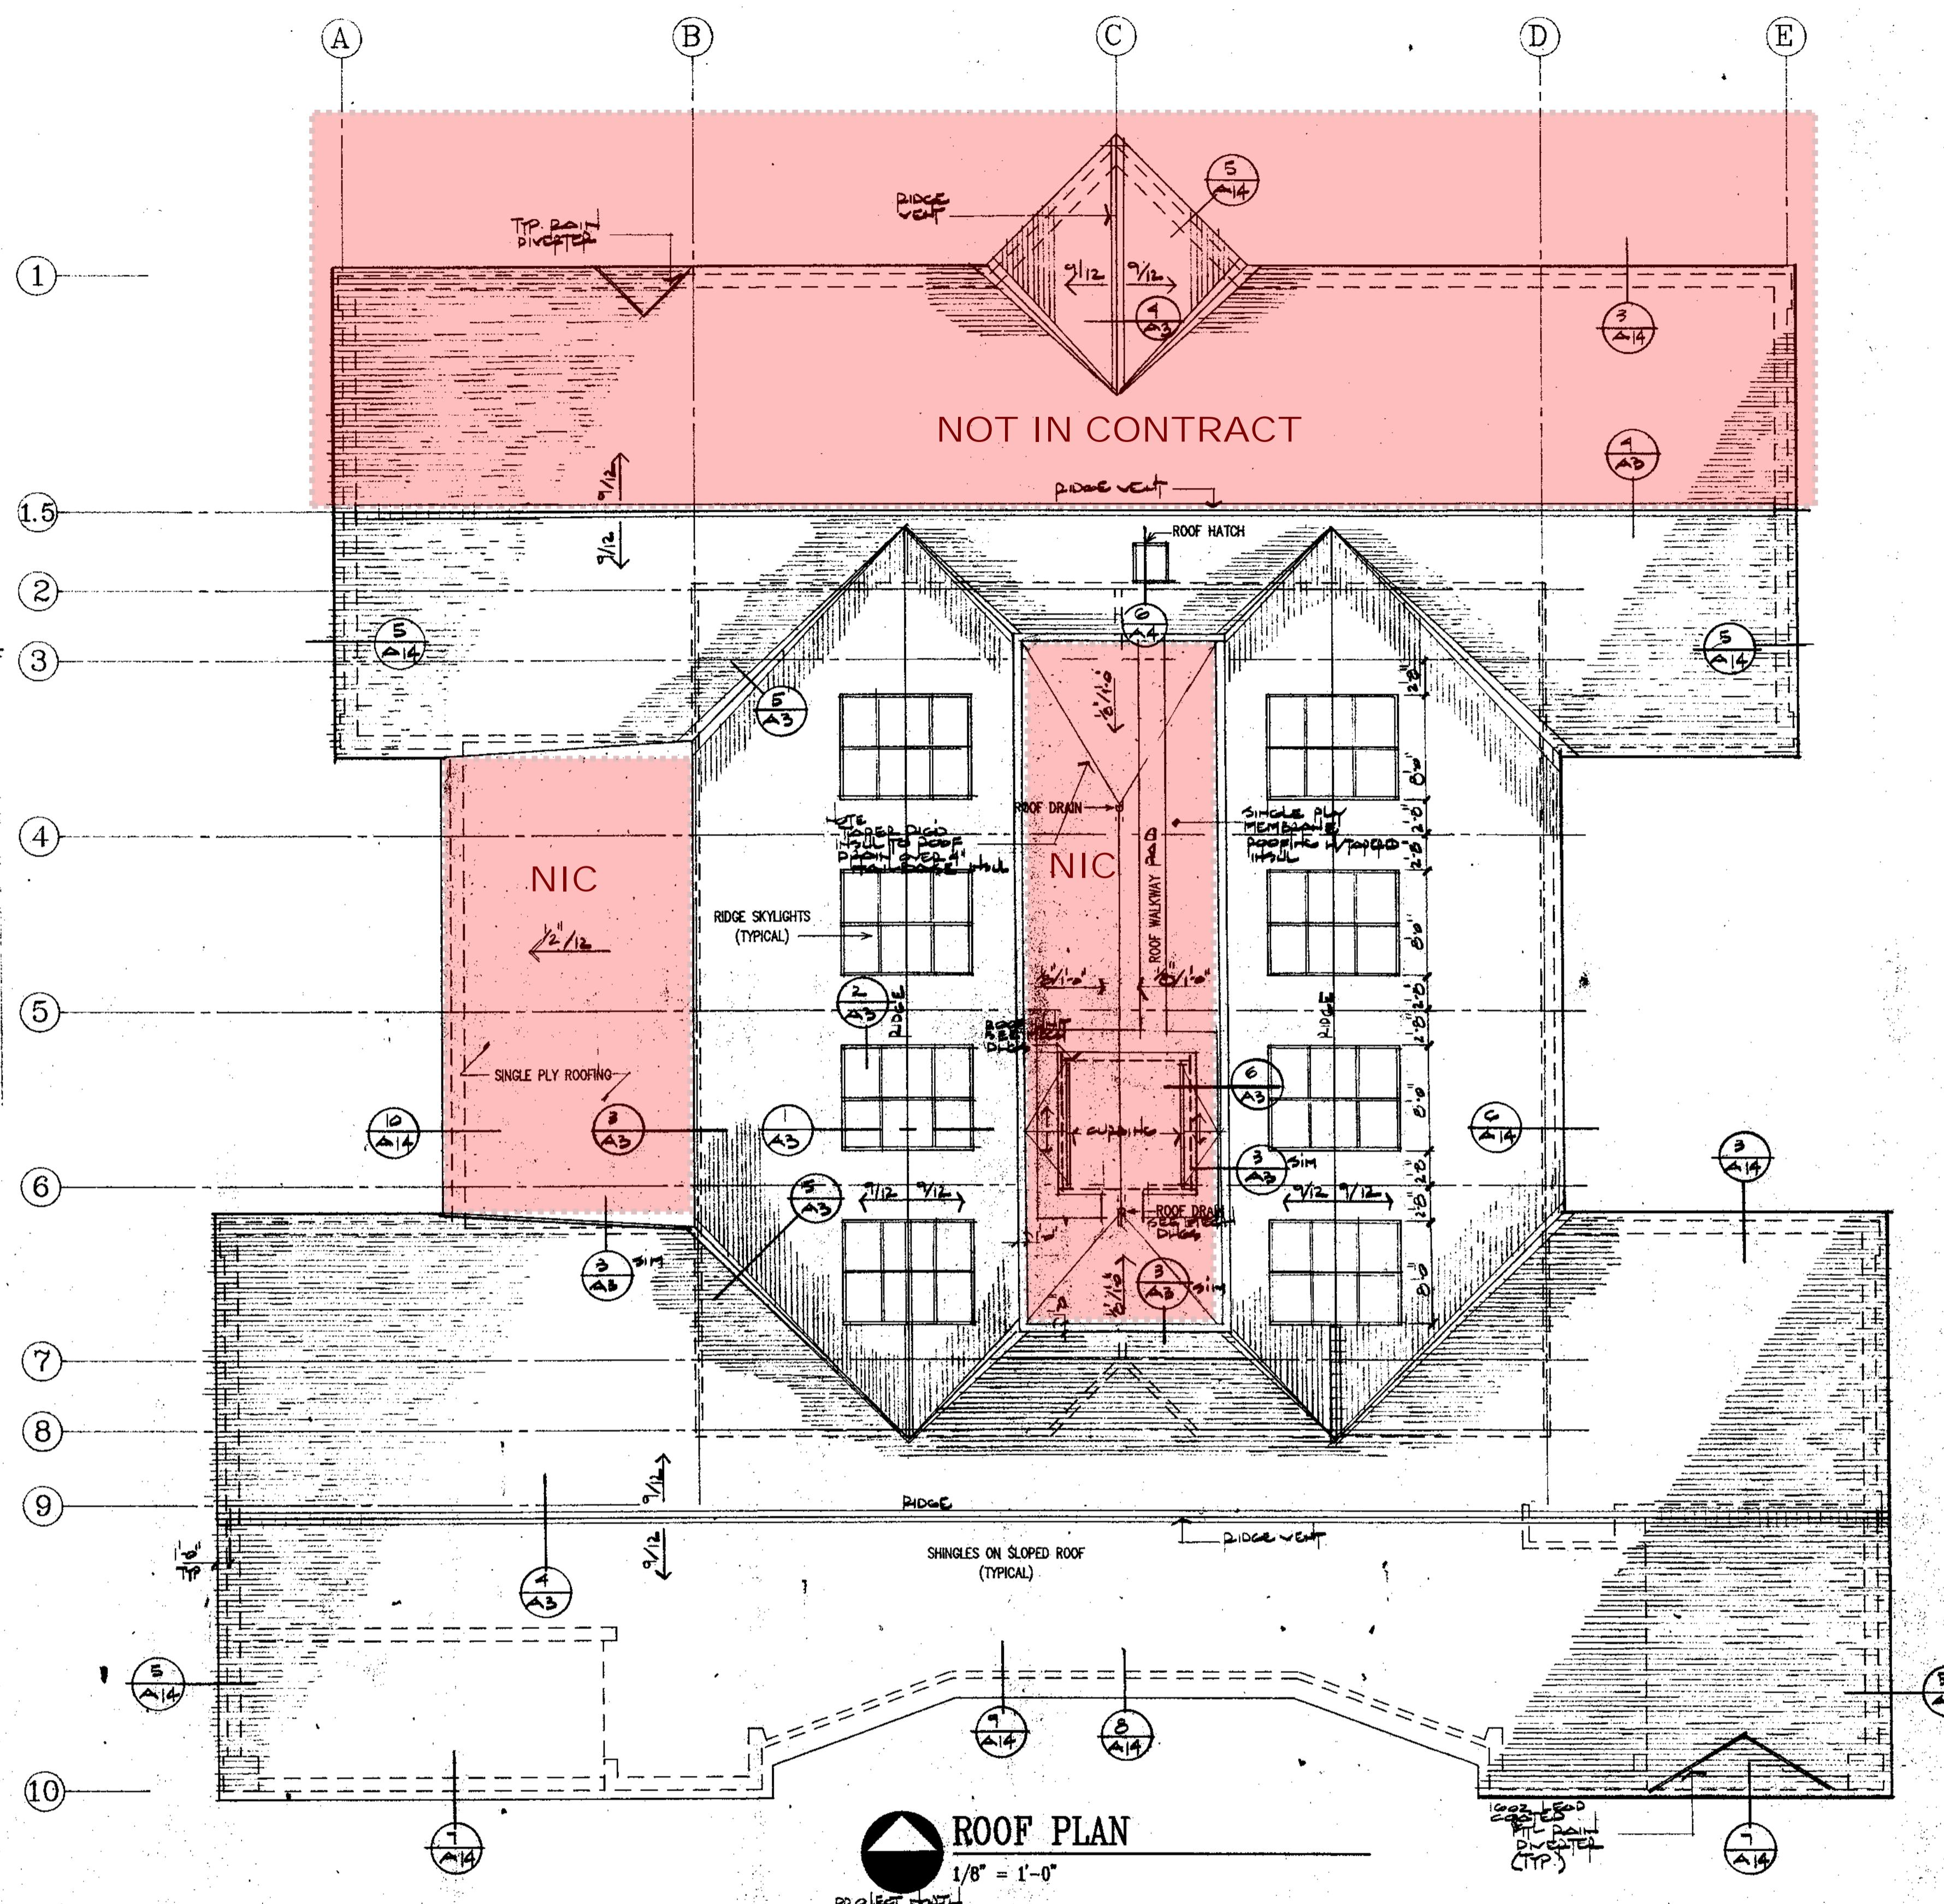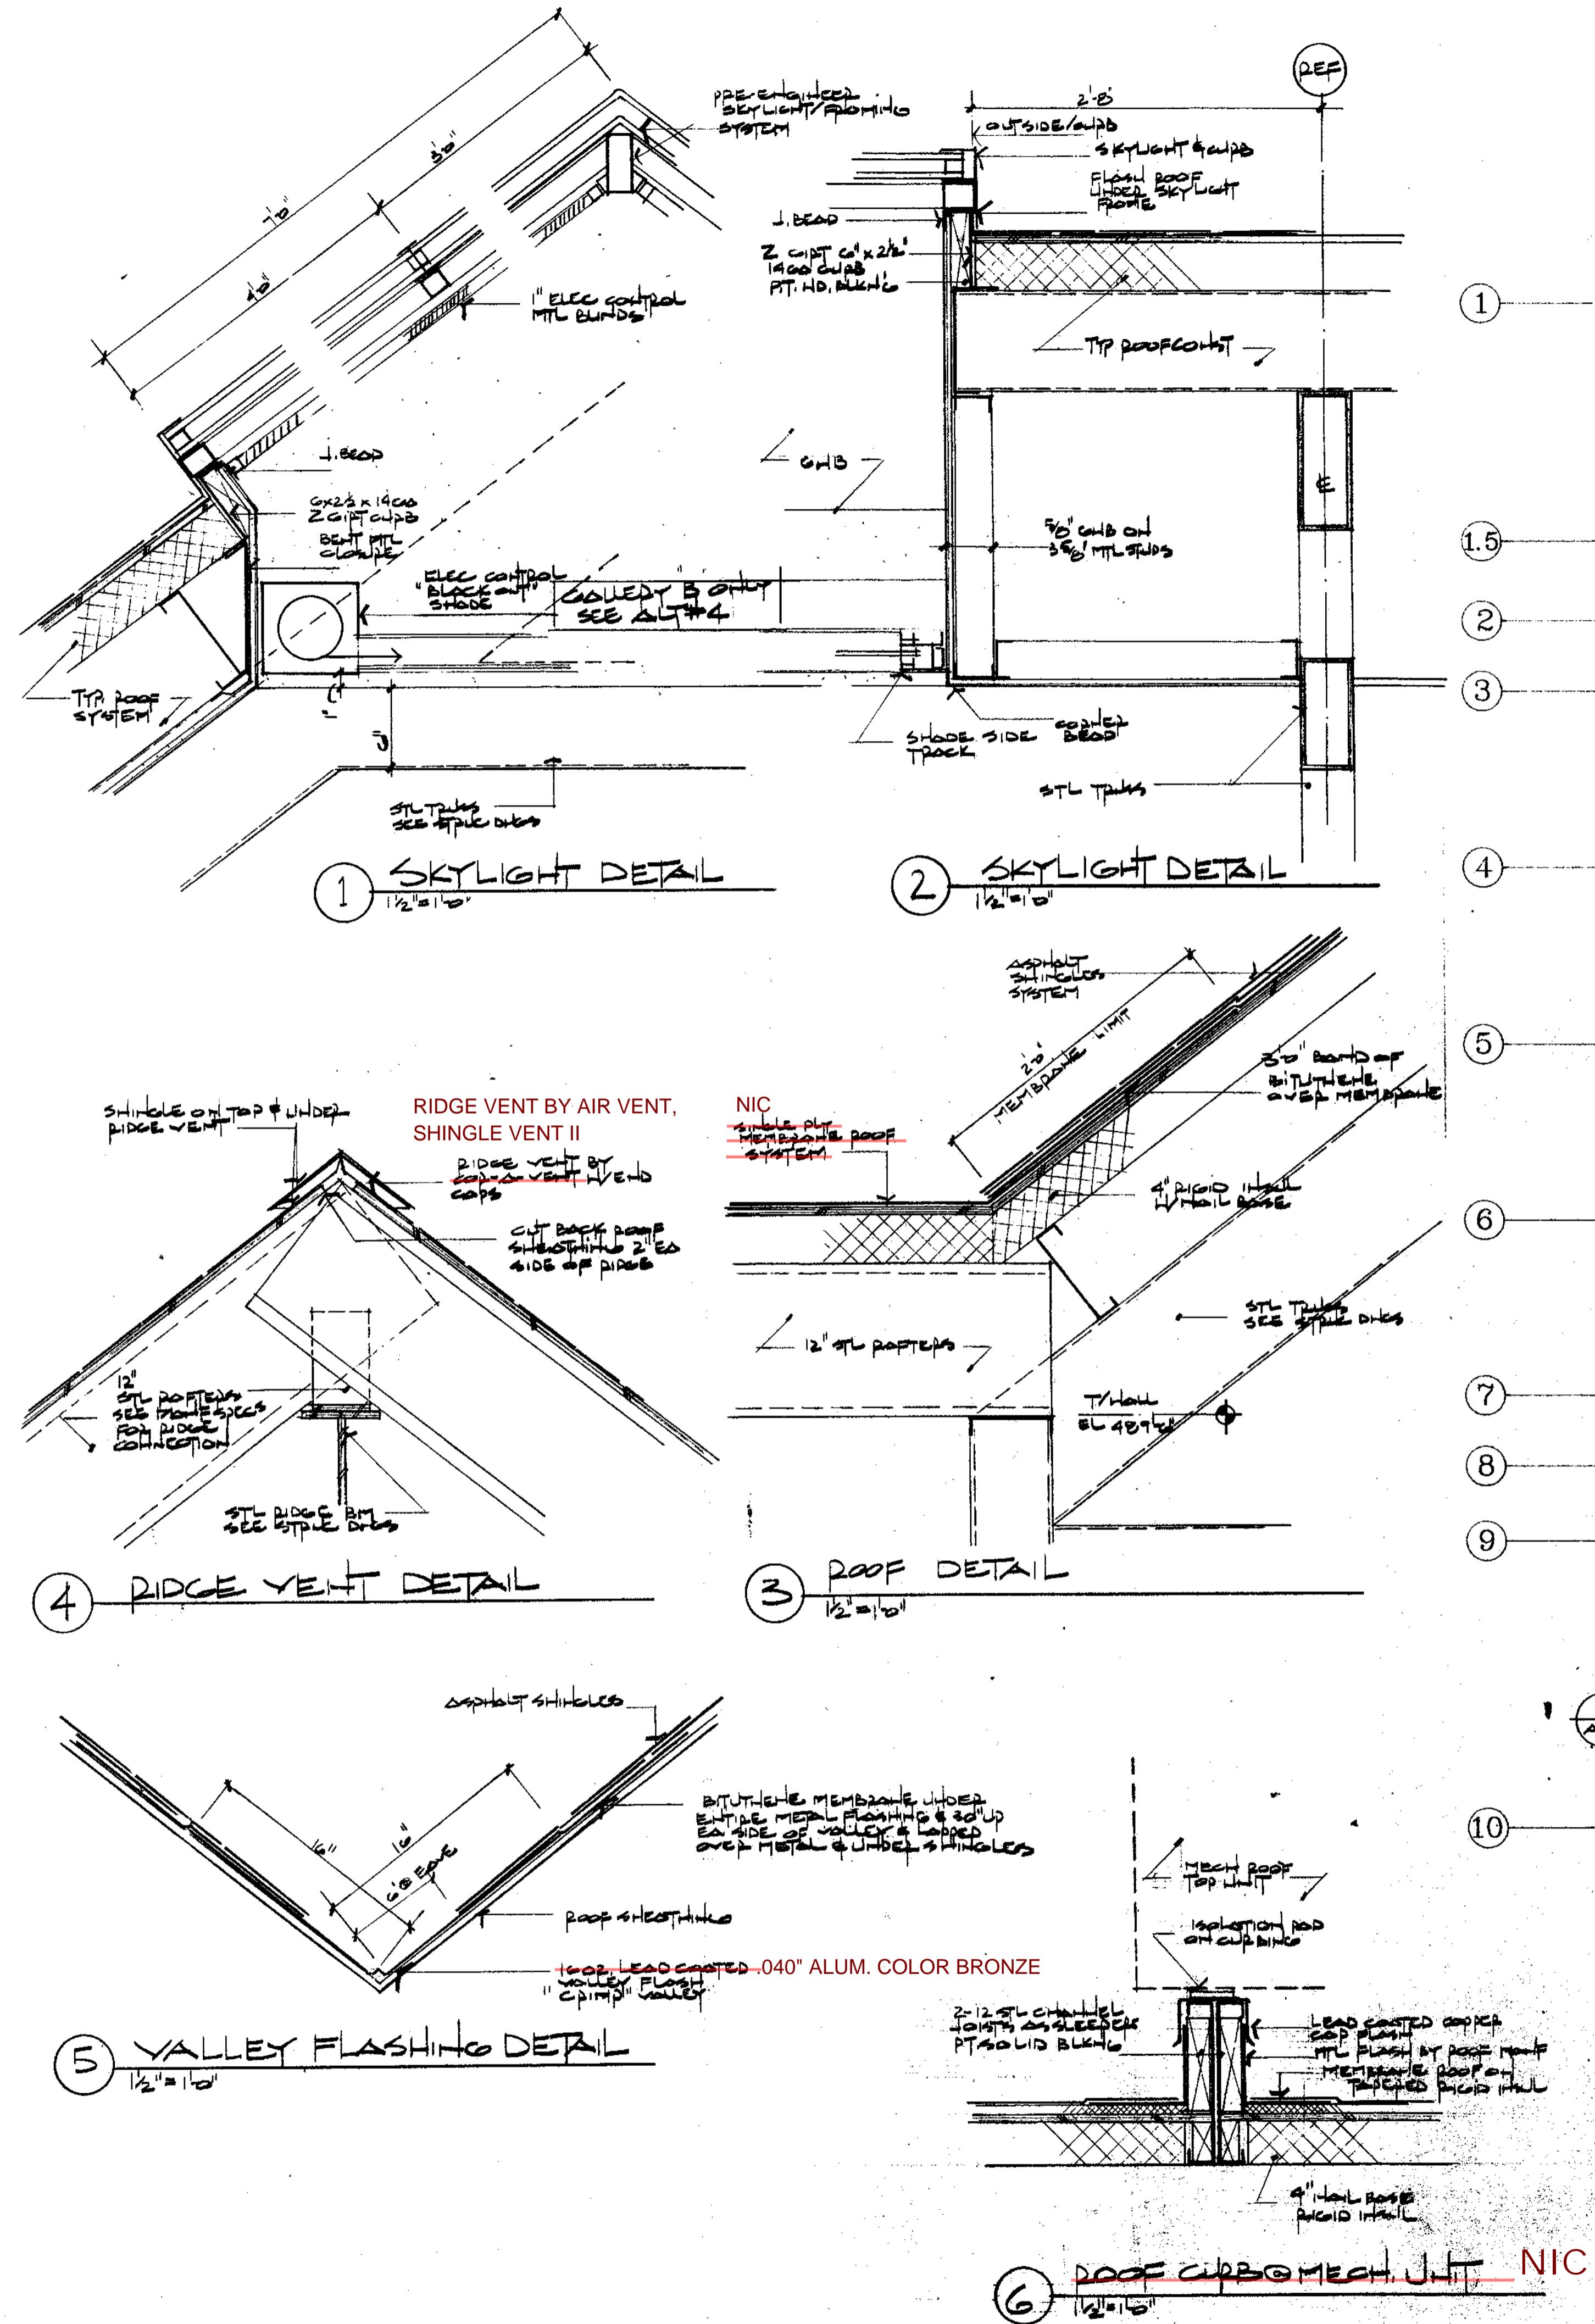


A3

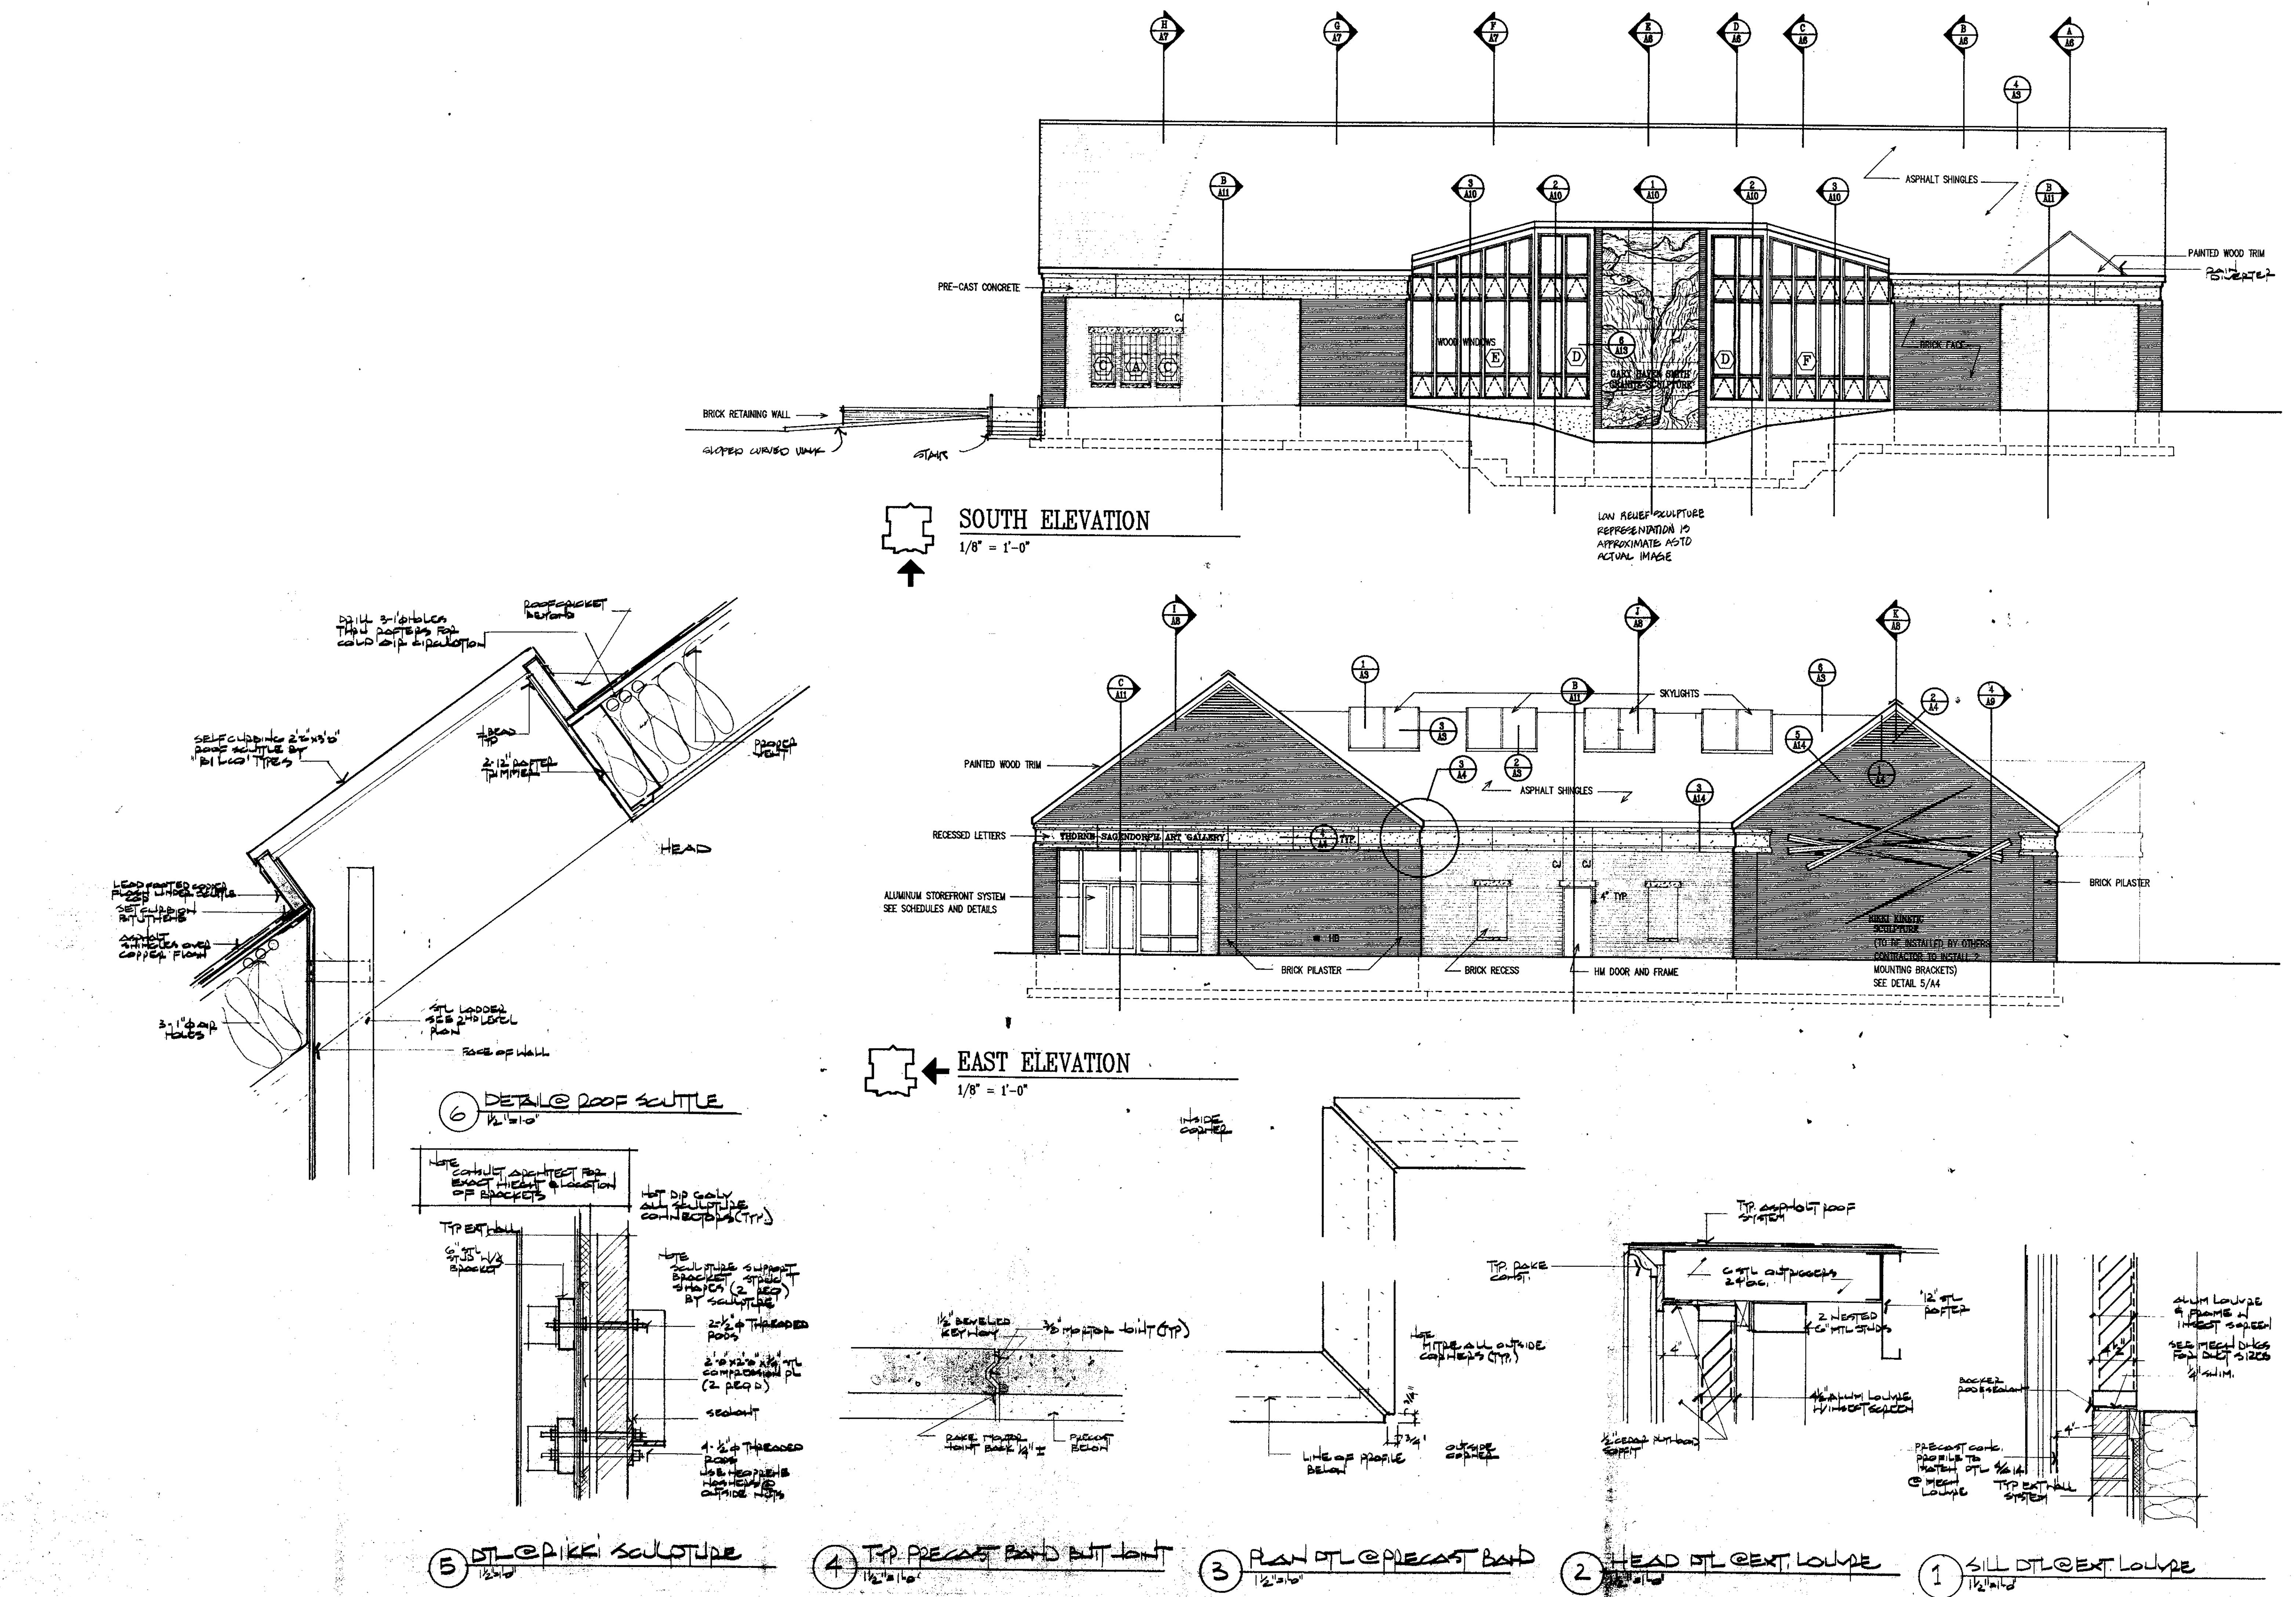


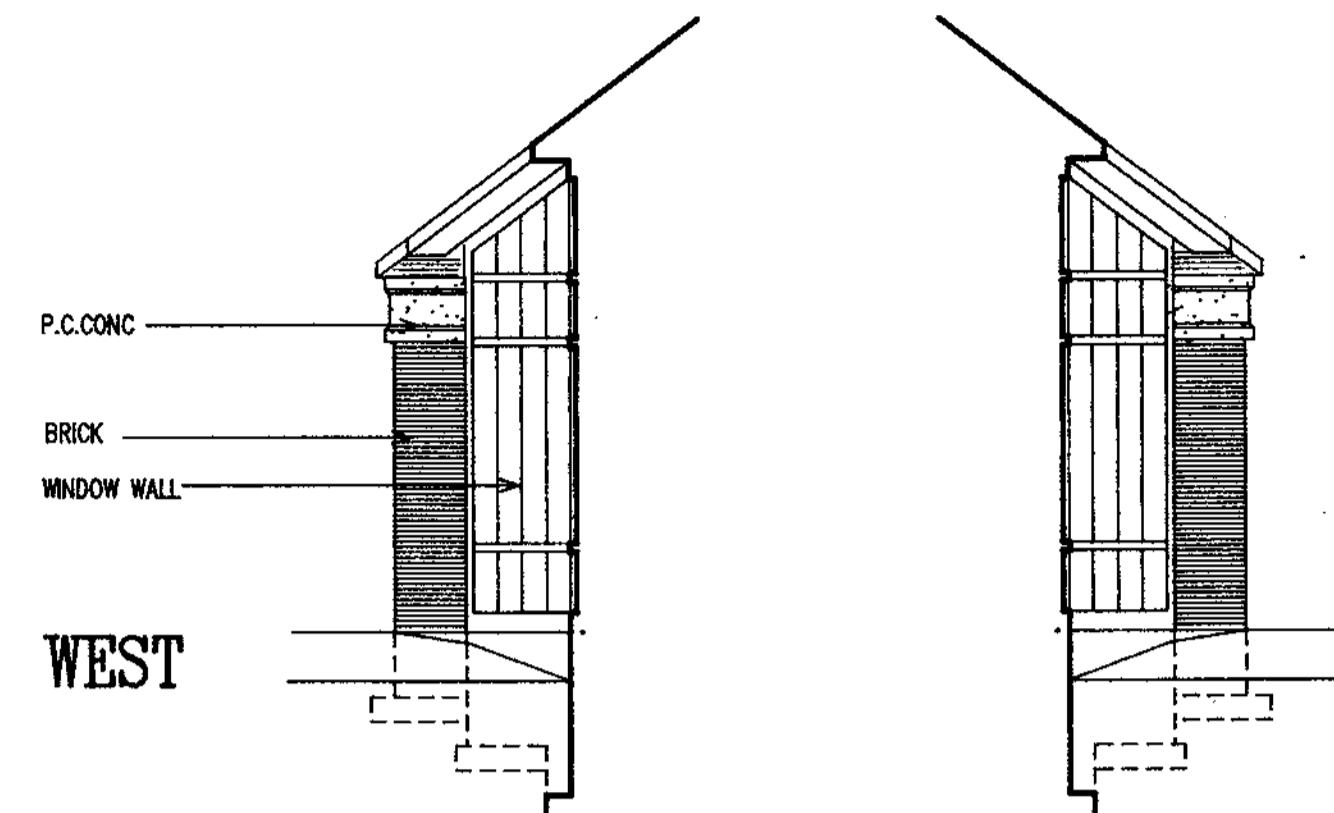


PARTIAL ELEVATIONS-WINDOW WALL
1/8" = 1'-0"

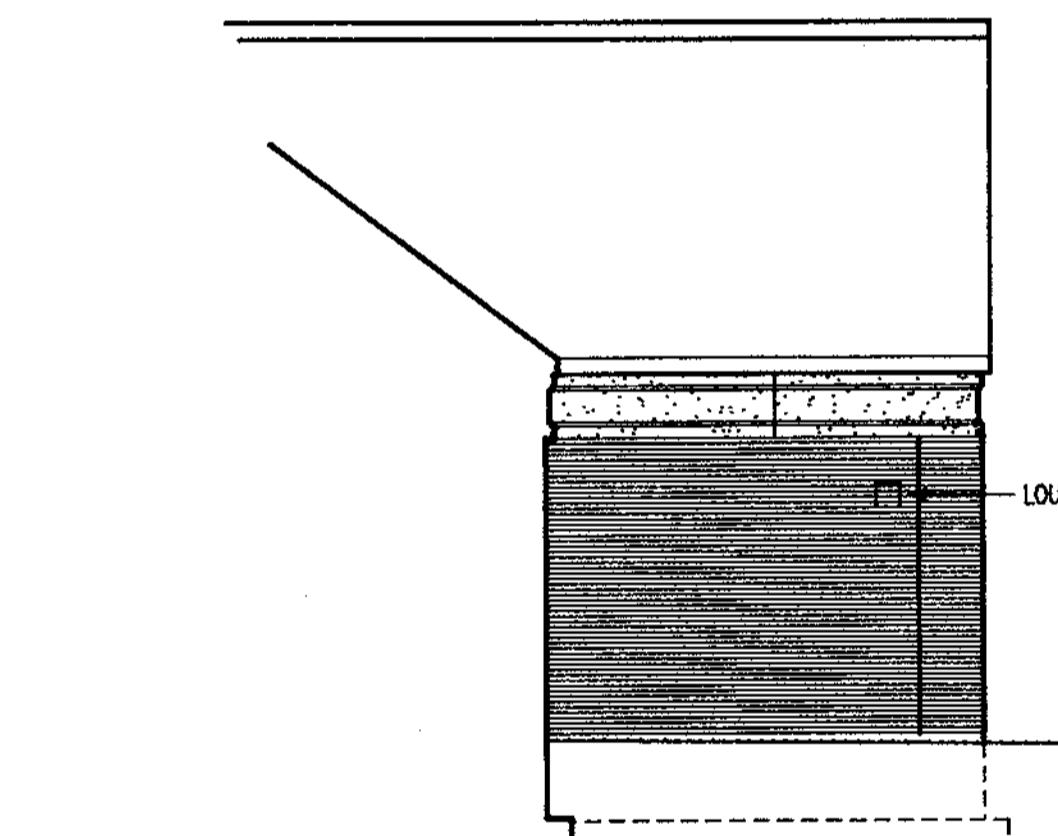


SOUTHEAST ELEVATION-NORTH WING
1/8" = 1'-0"

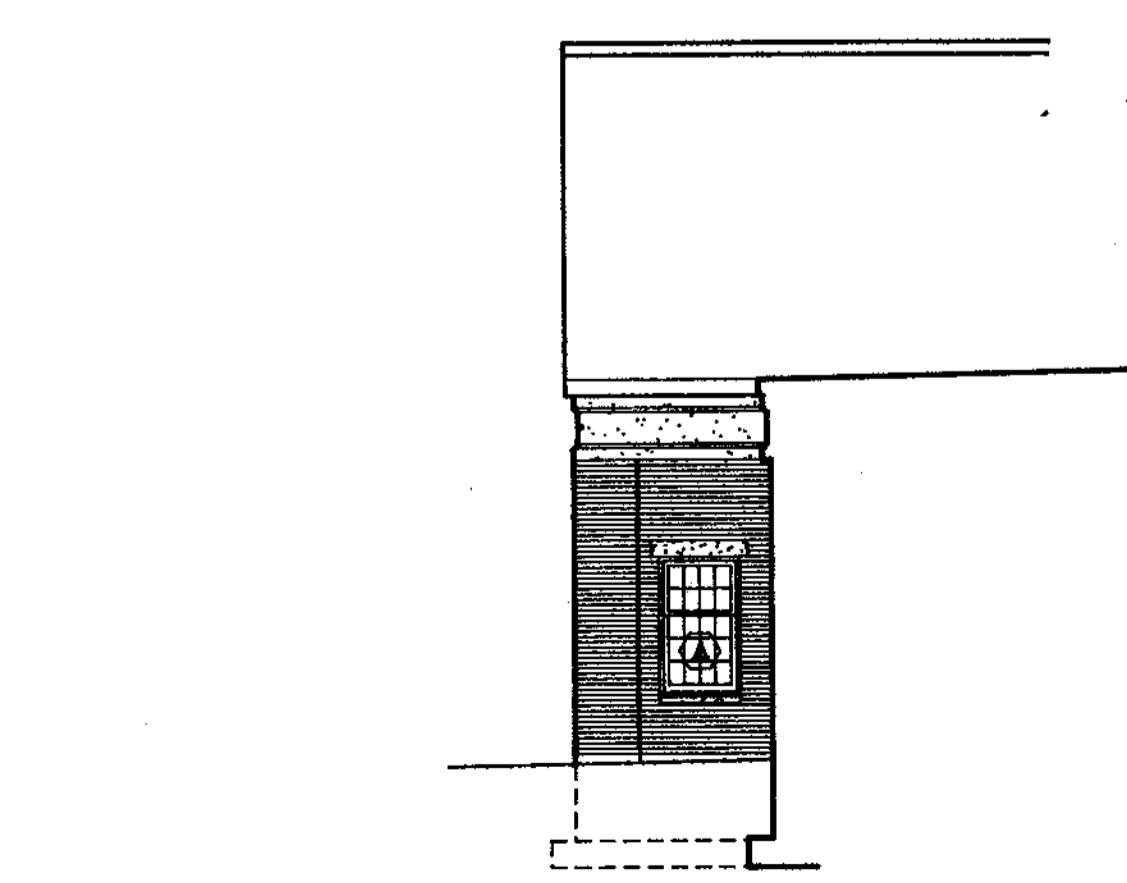


SOUTHWEST ELEVATION-NORTH WING
1/8" = 1'-0"

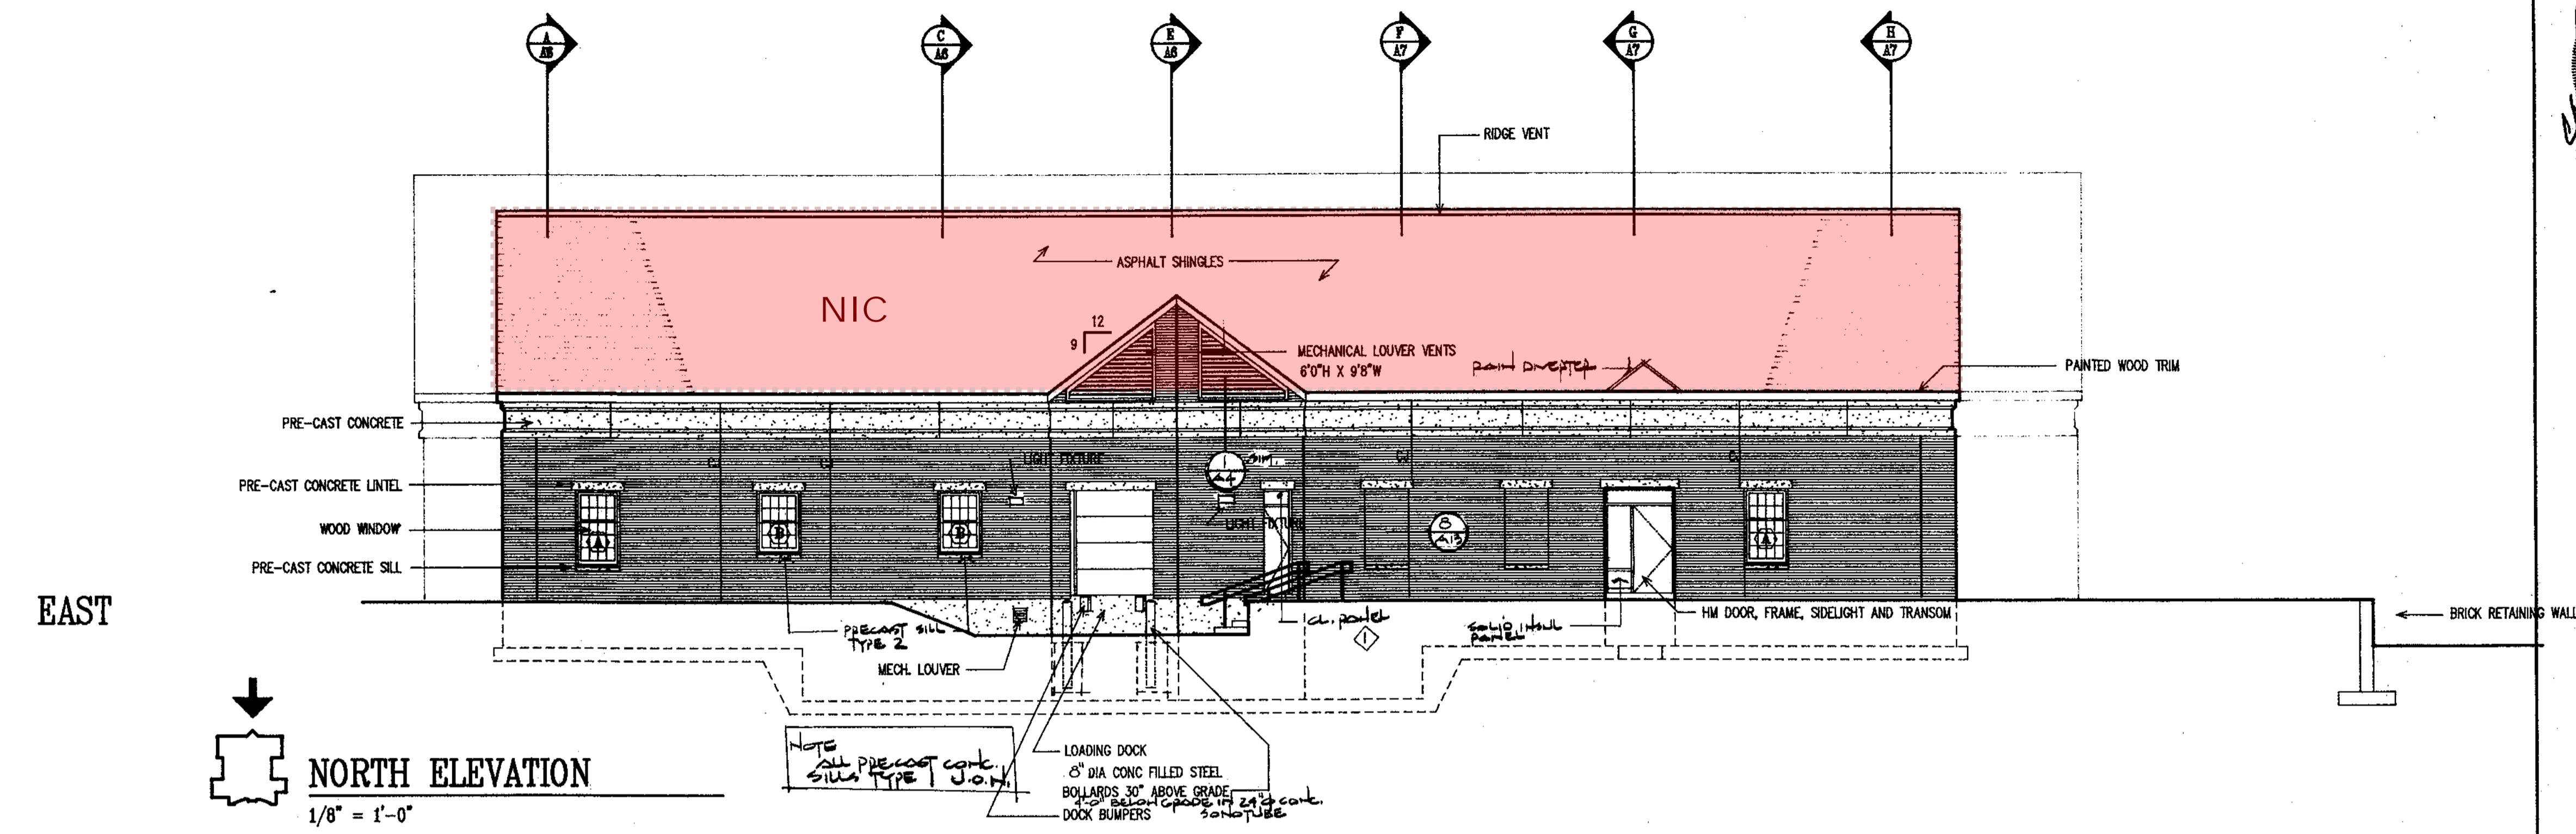


NORTH ELEVATION
1/8" = 1'-0"

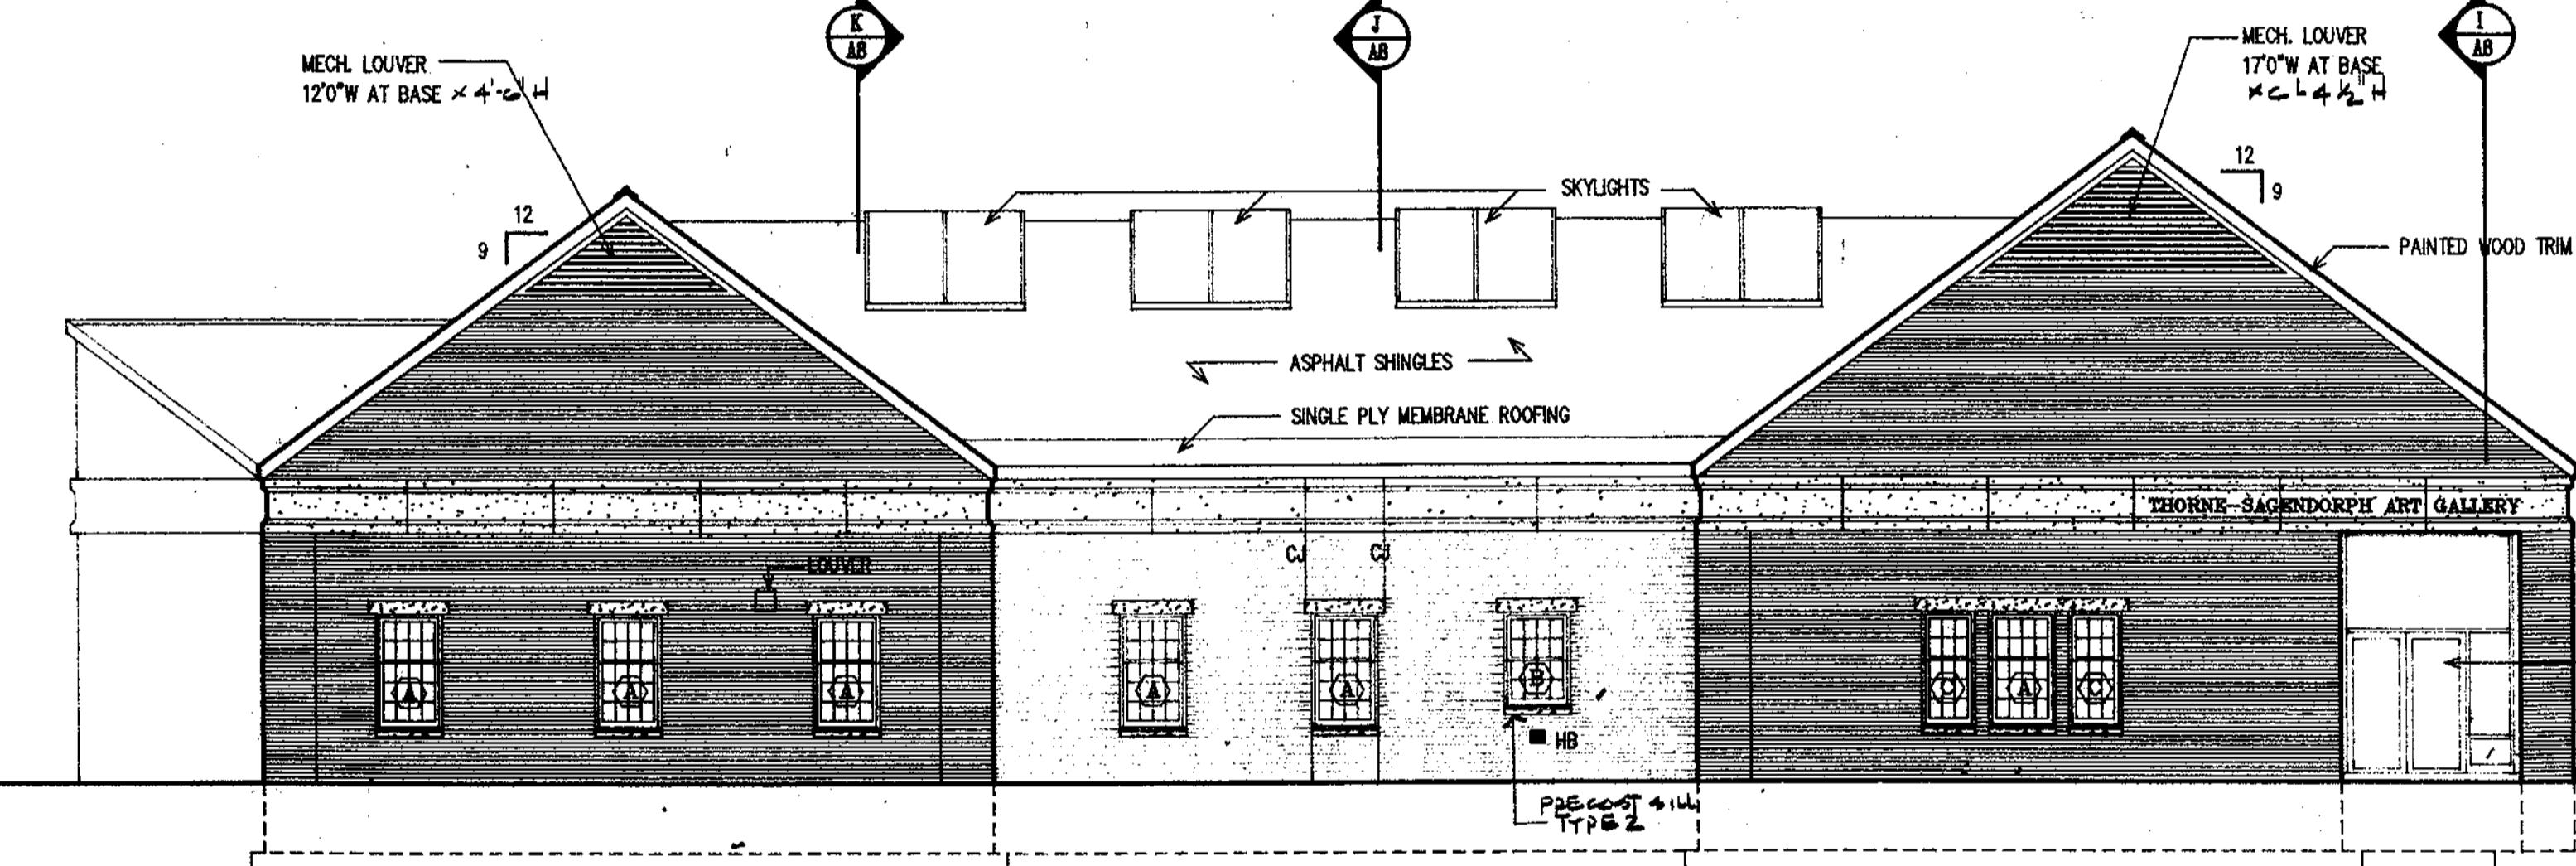

WEST ELEVATION
1/8" = 1'-0"

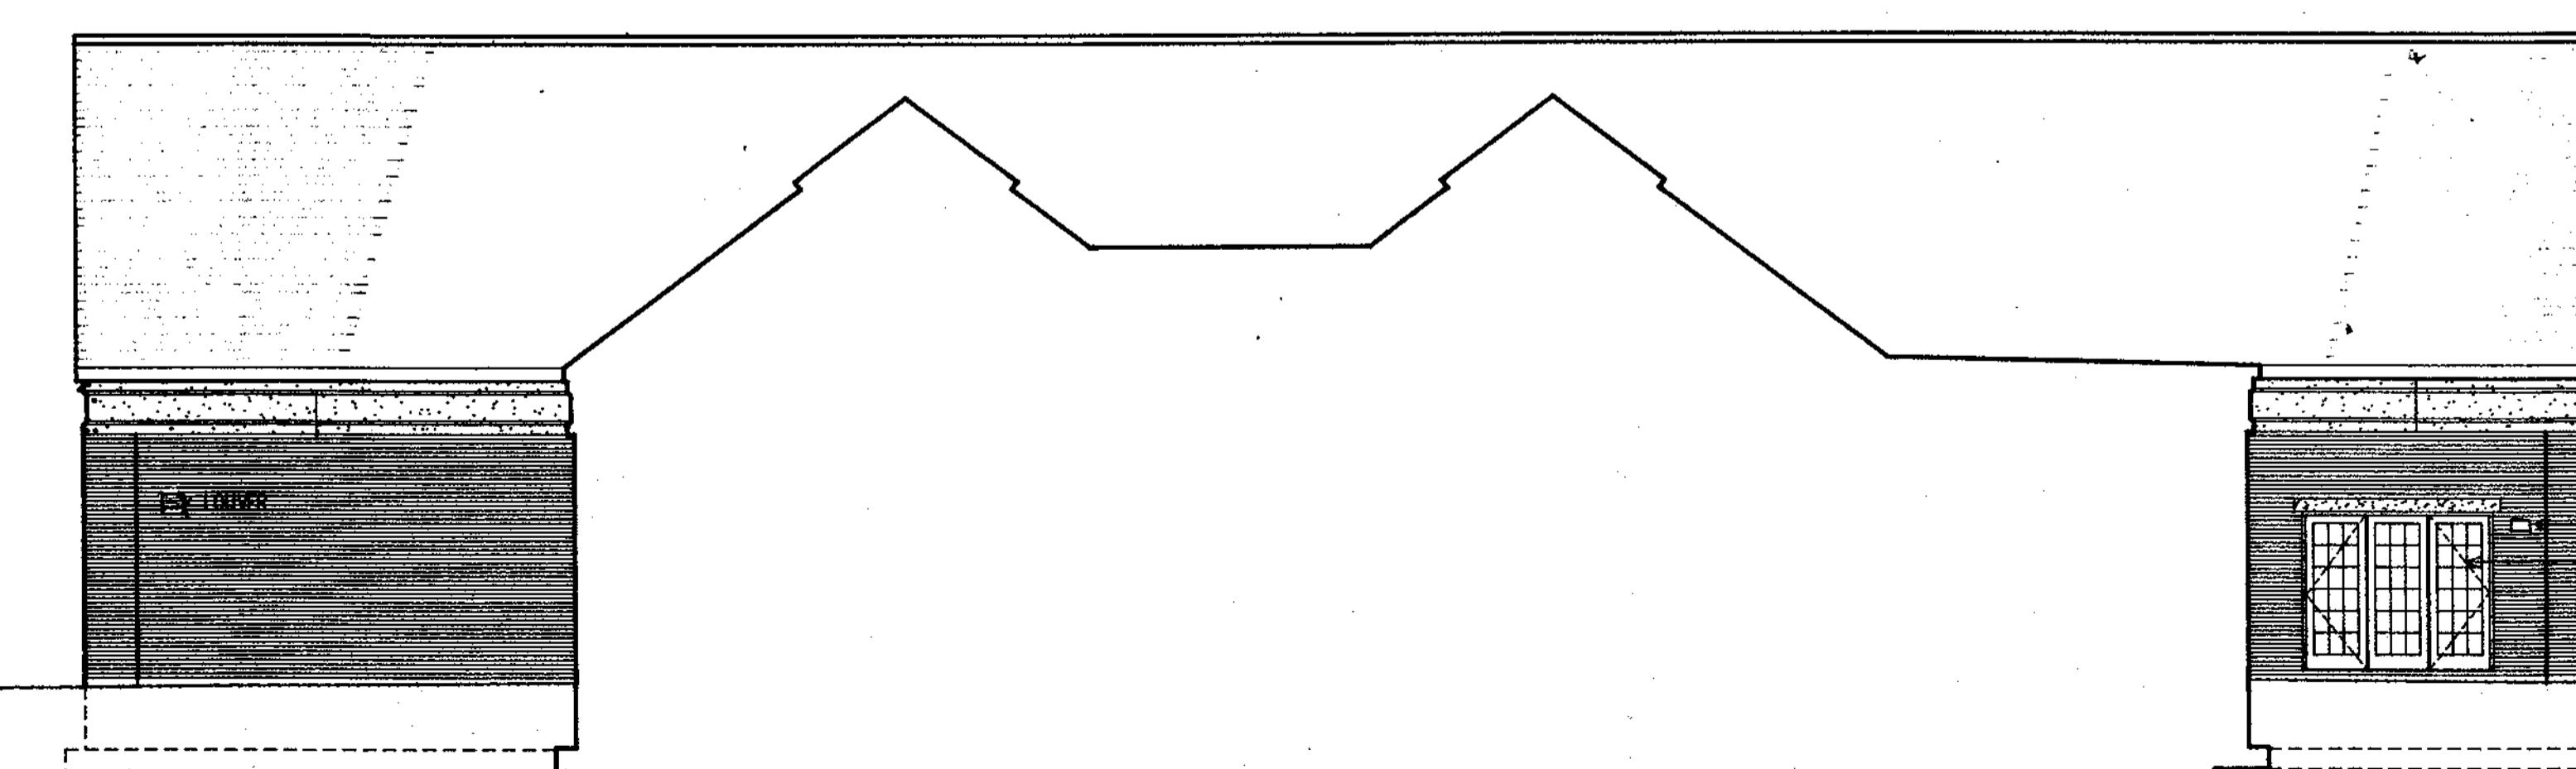


NORTH ELEVATION AT SOUTH WING
1/8" = 1'-0"

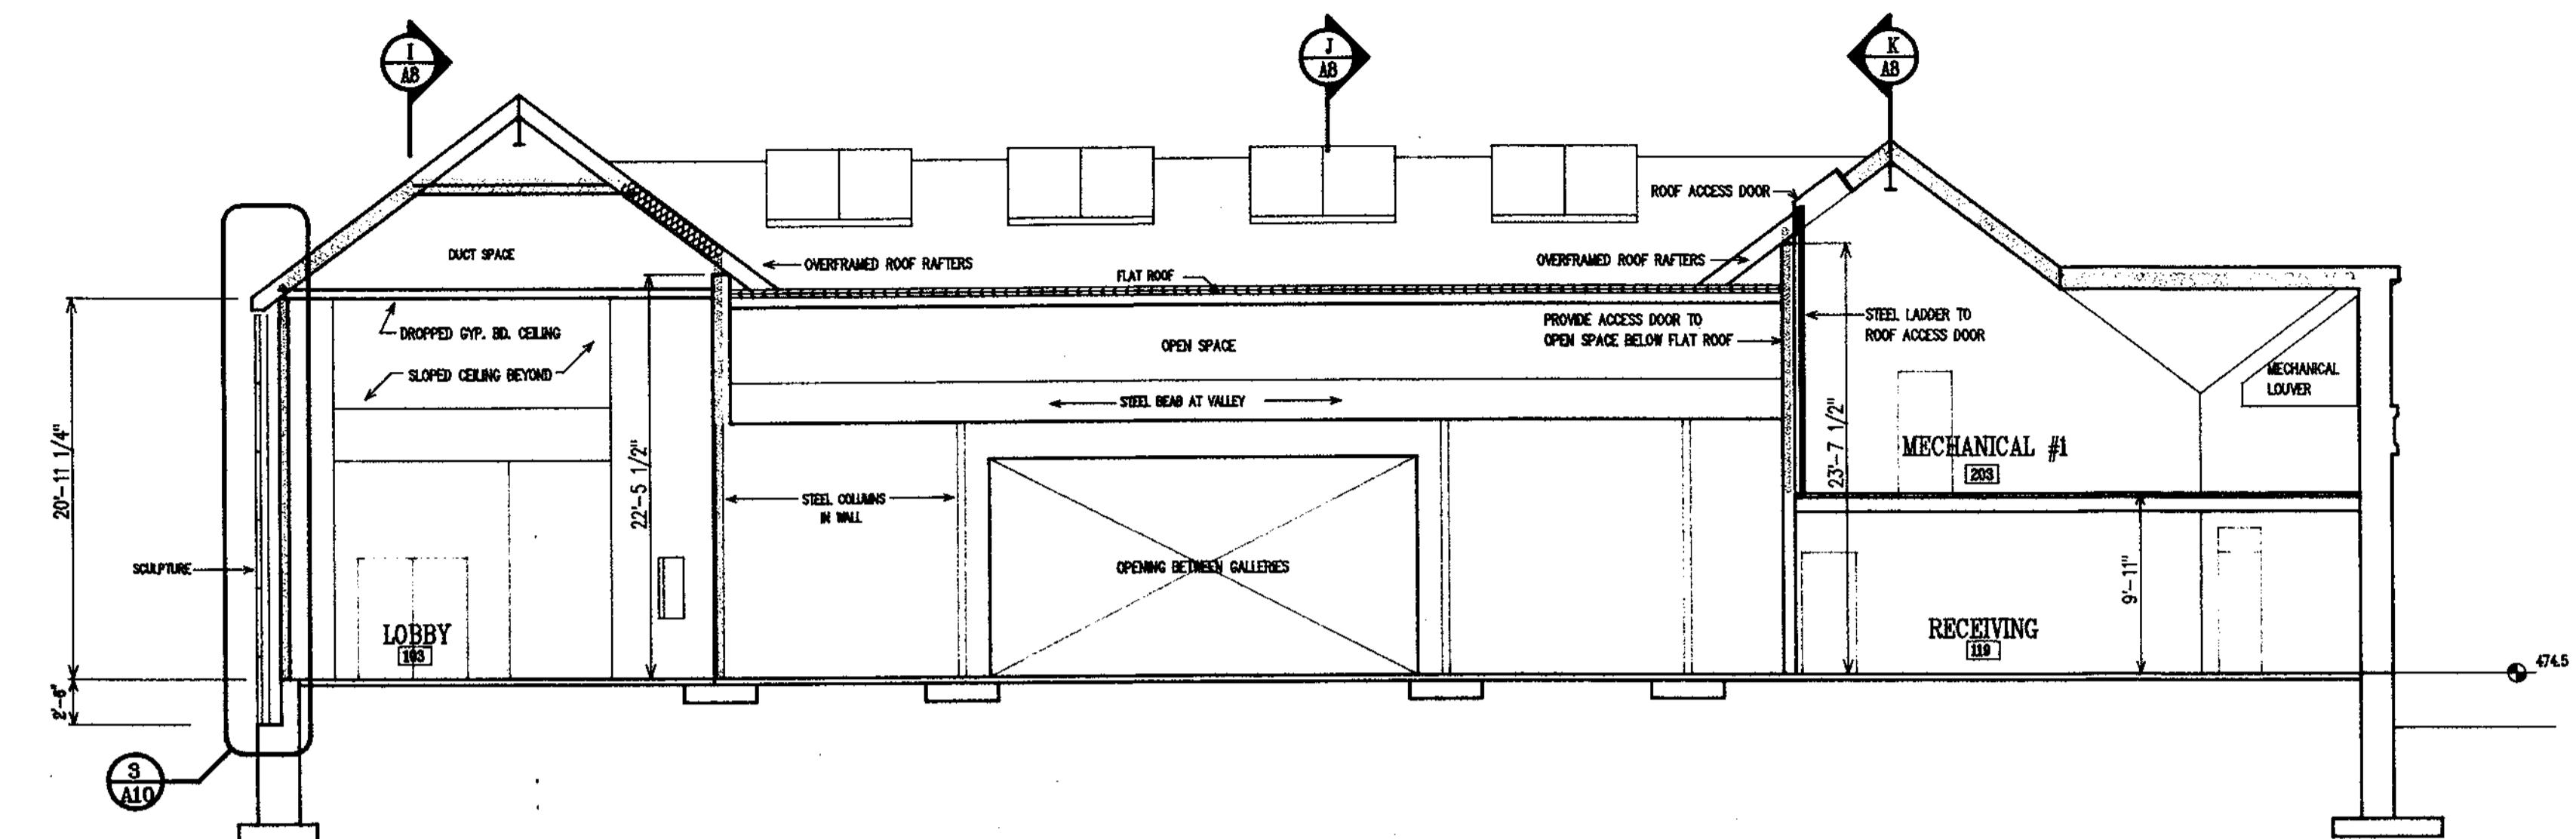


SECTION E

1/8" = 1'-0"

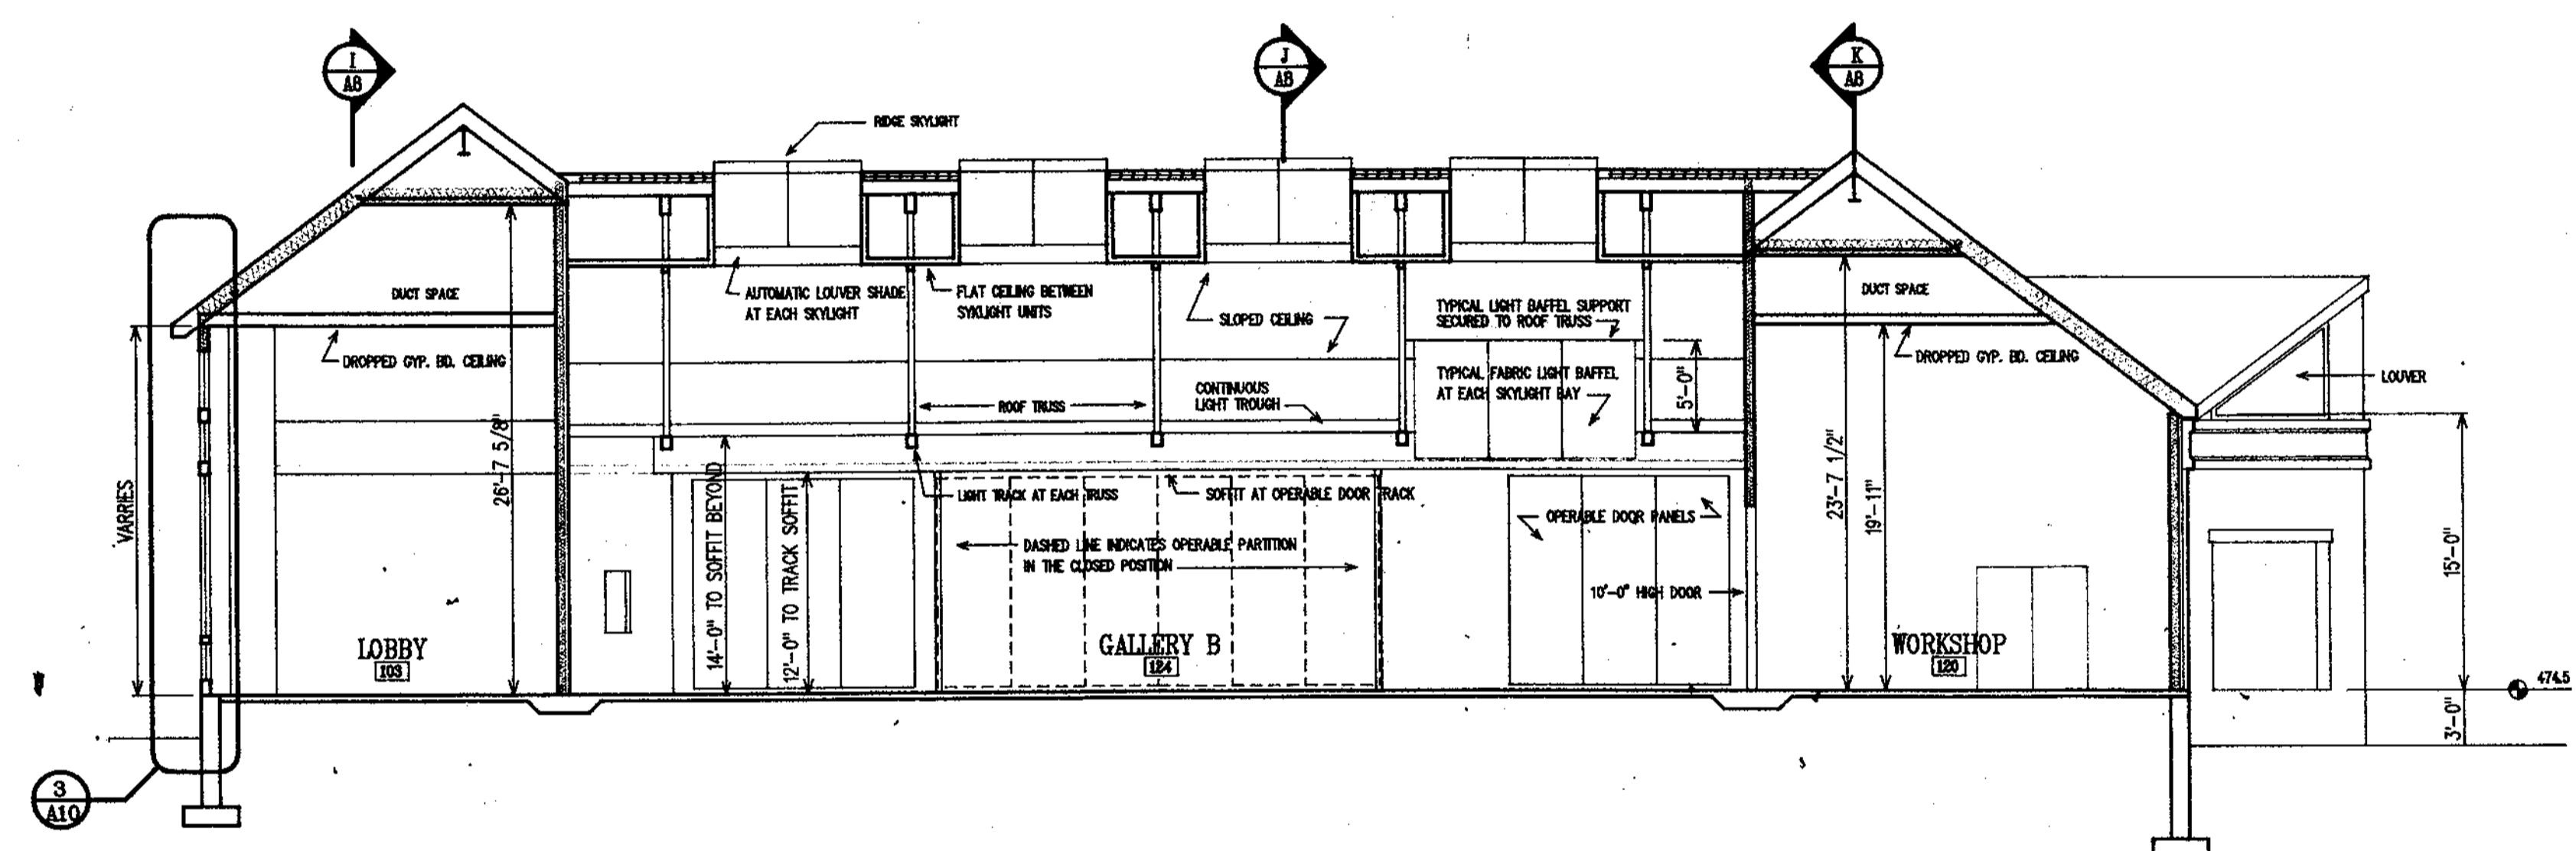


SECTION C

1/8" = 1'-0"

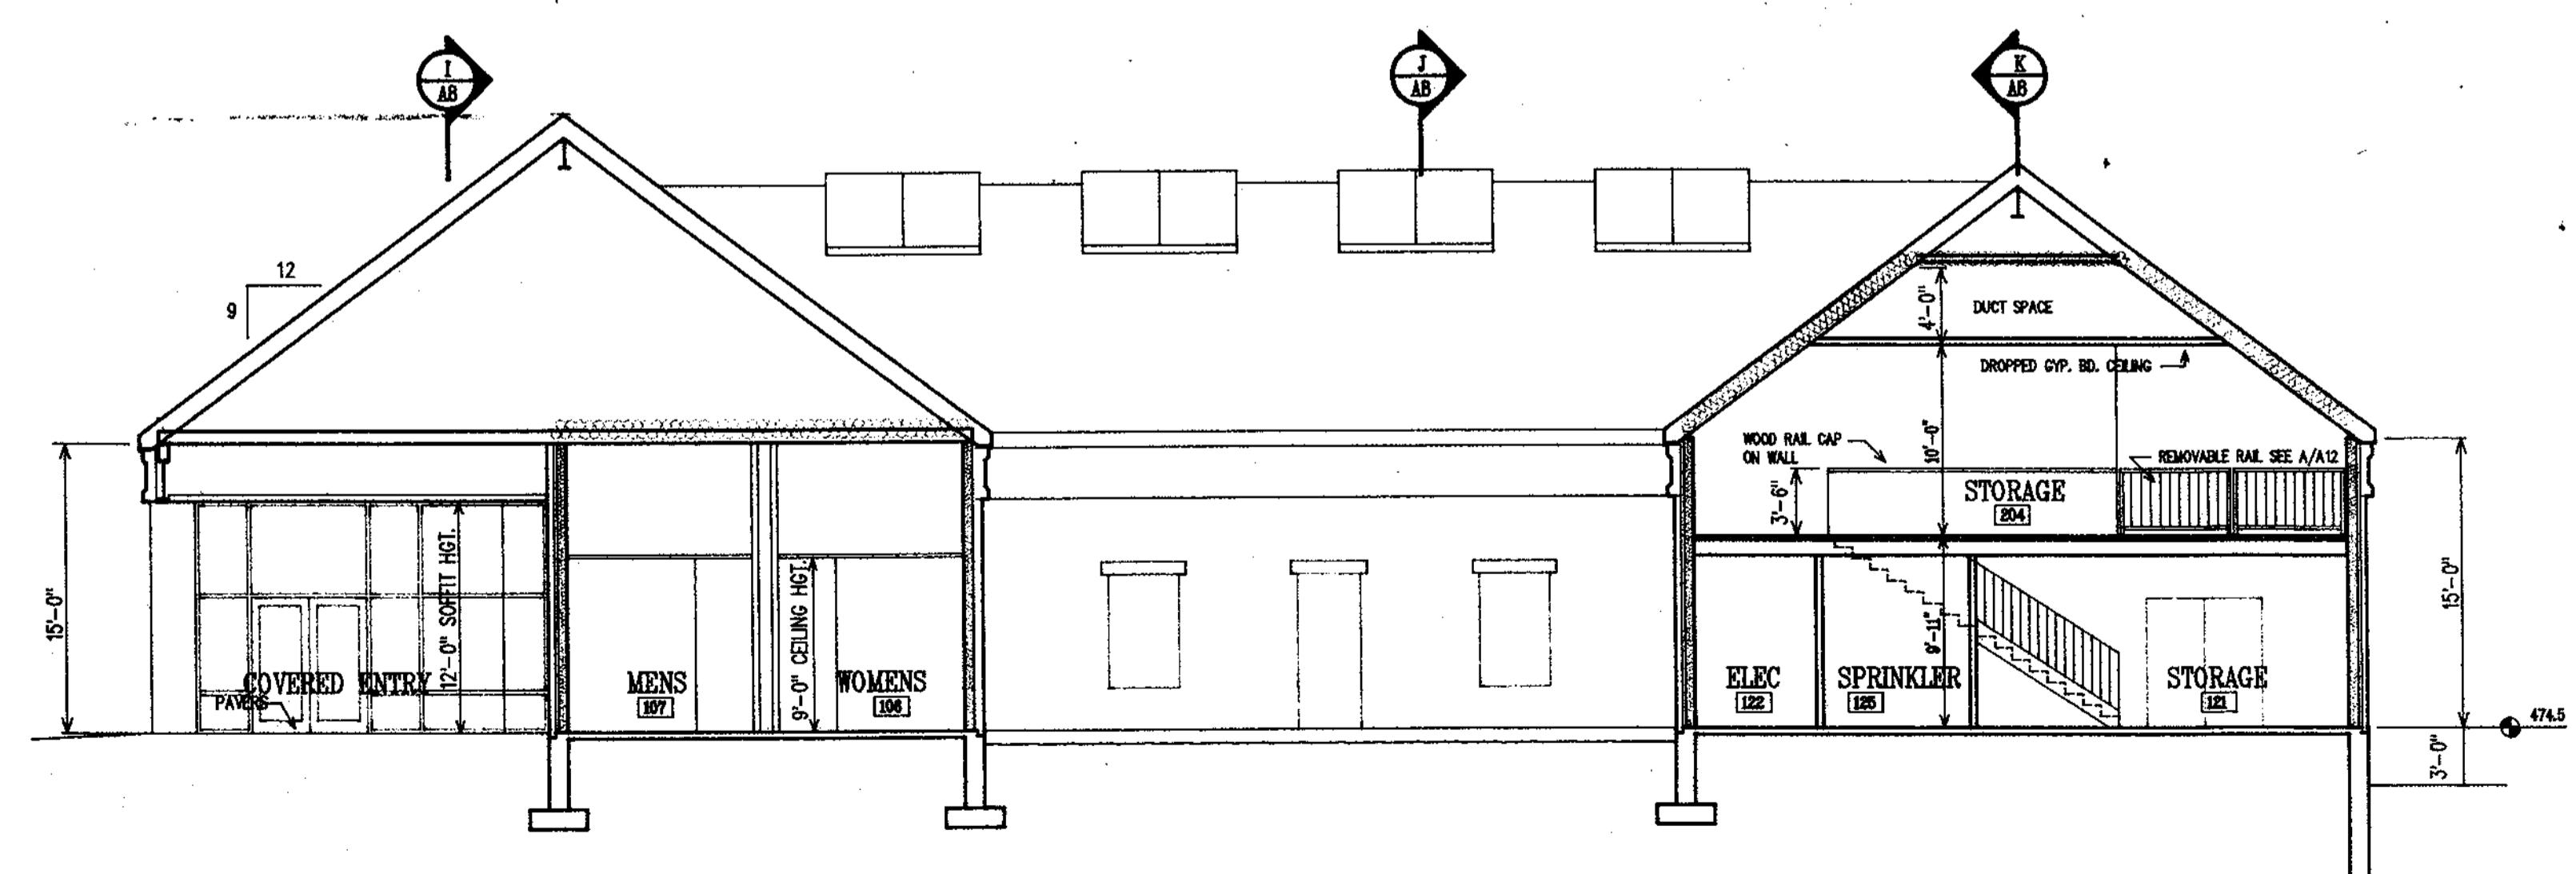


SECTION A

1/8" = 1'-0"

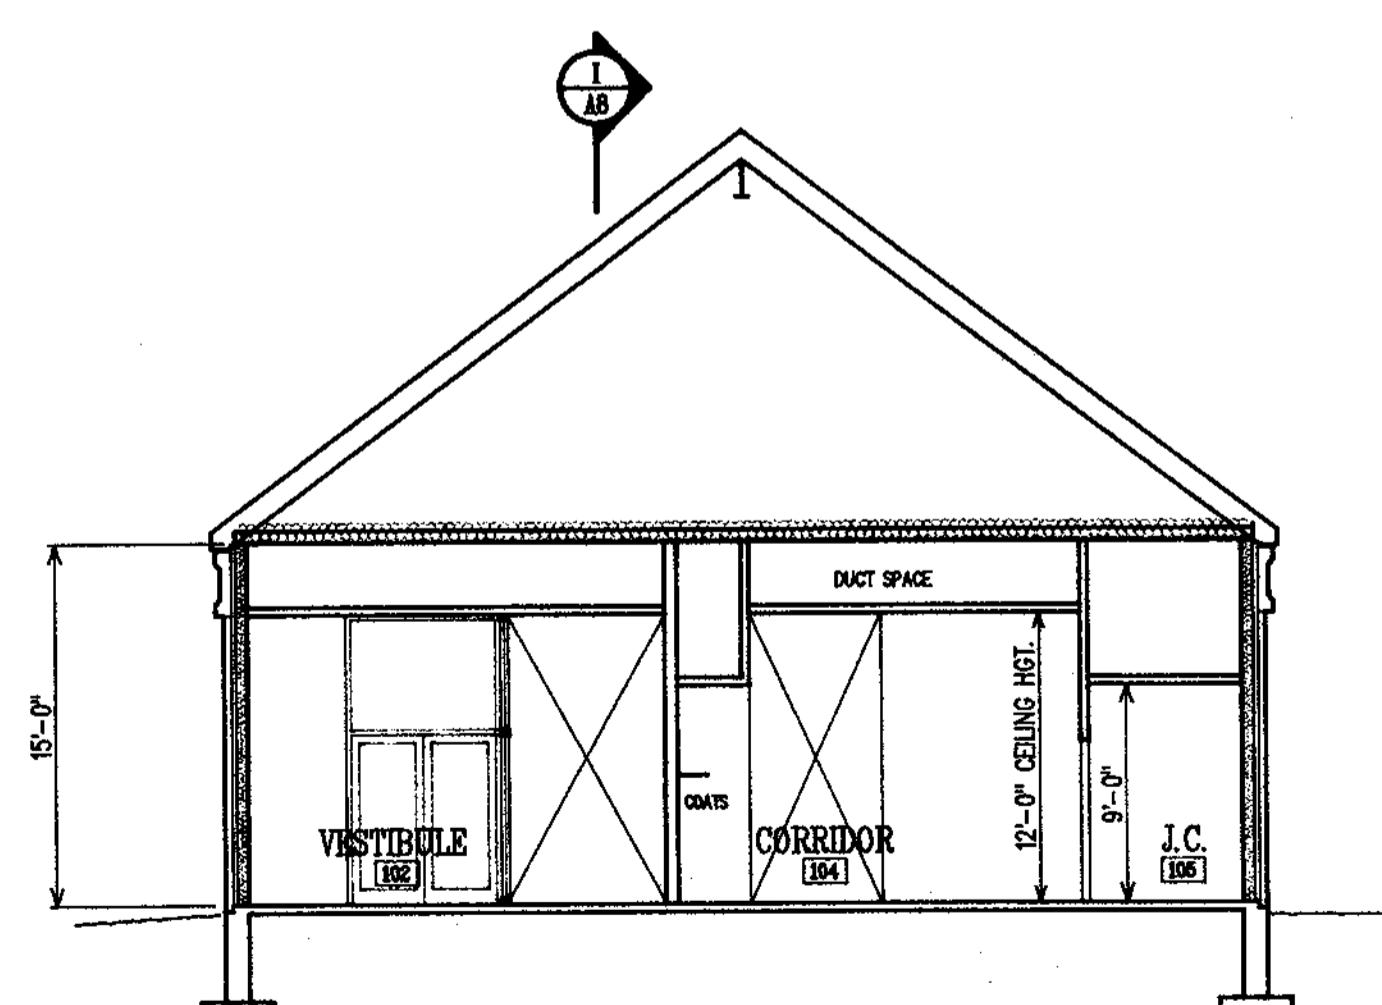


SECTION B

1/8" = 1'-0"

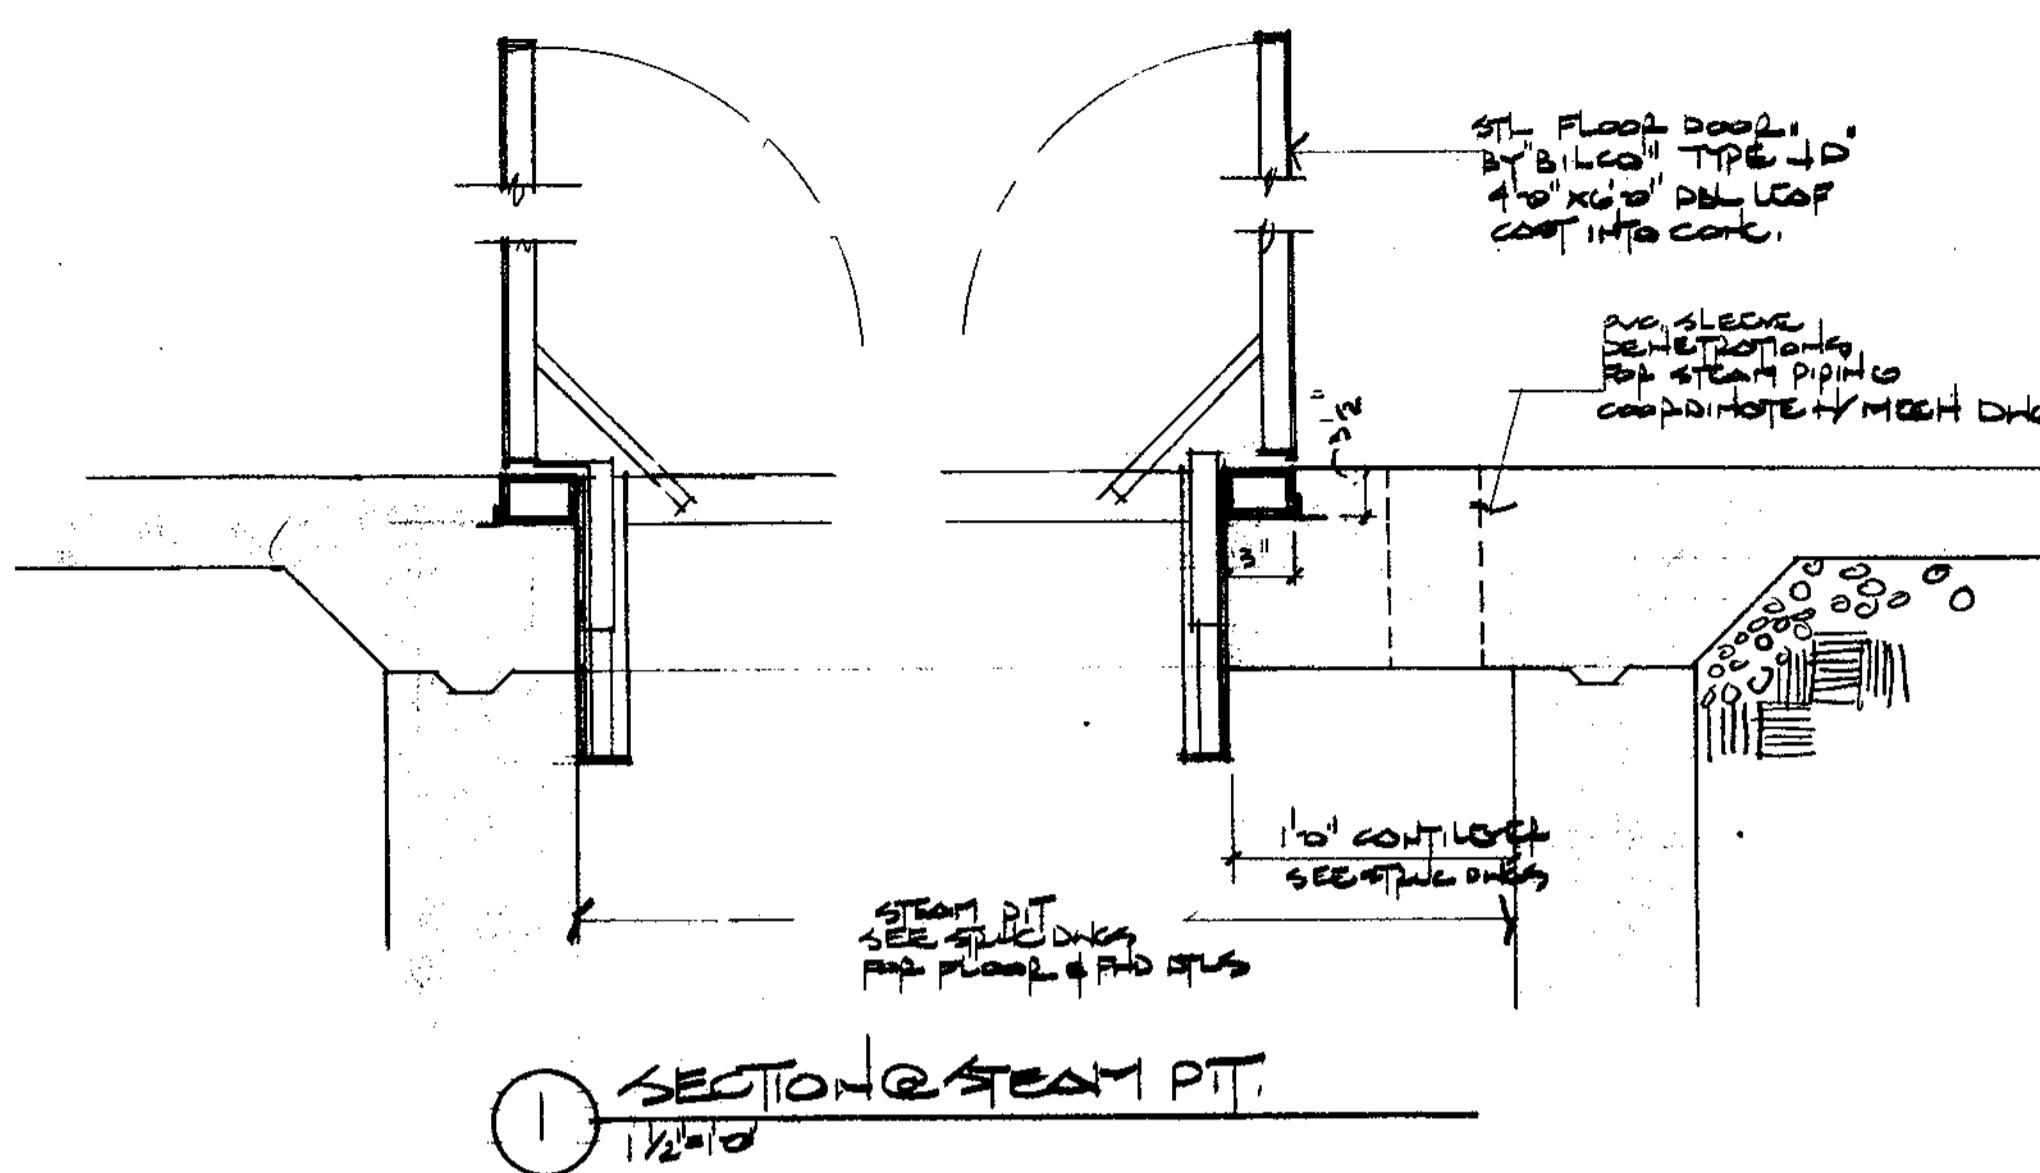


SECTION D

1/8" = 1'-0"

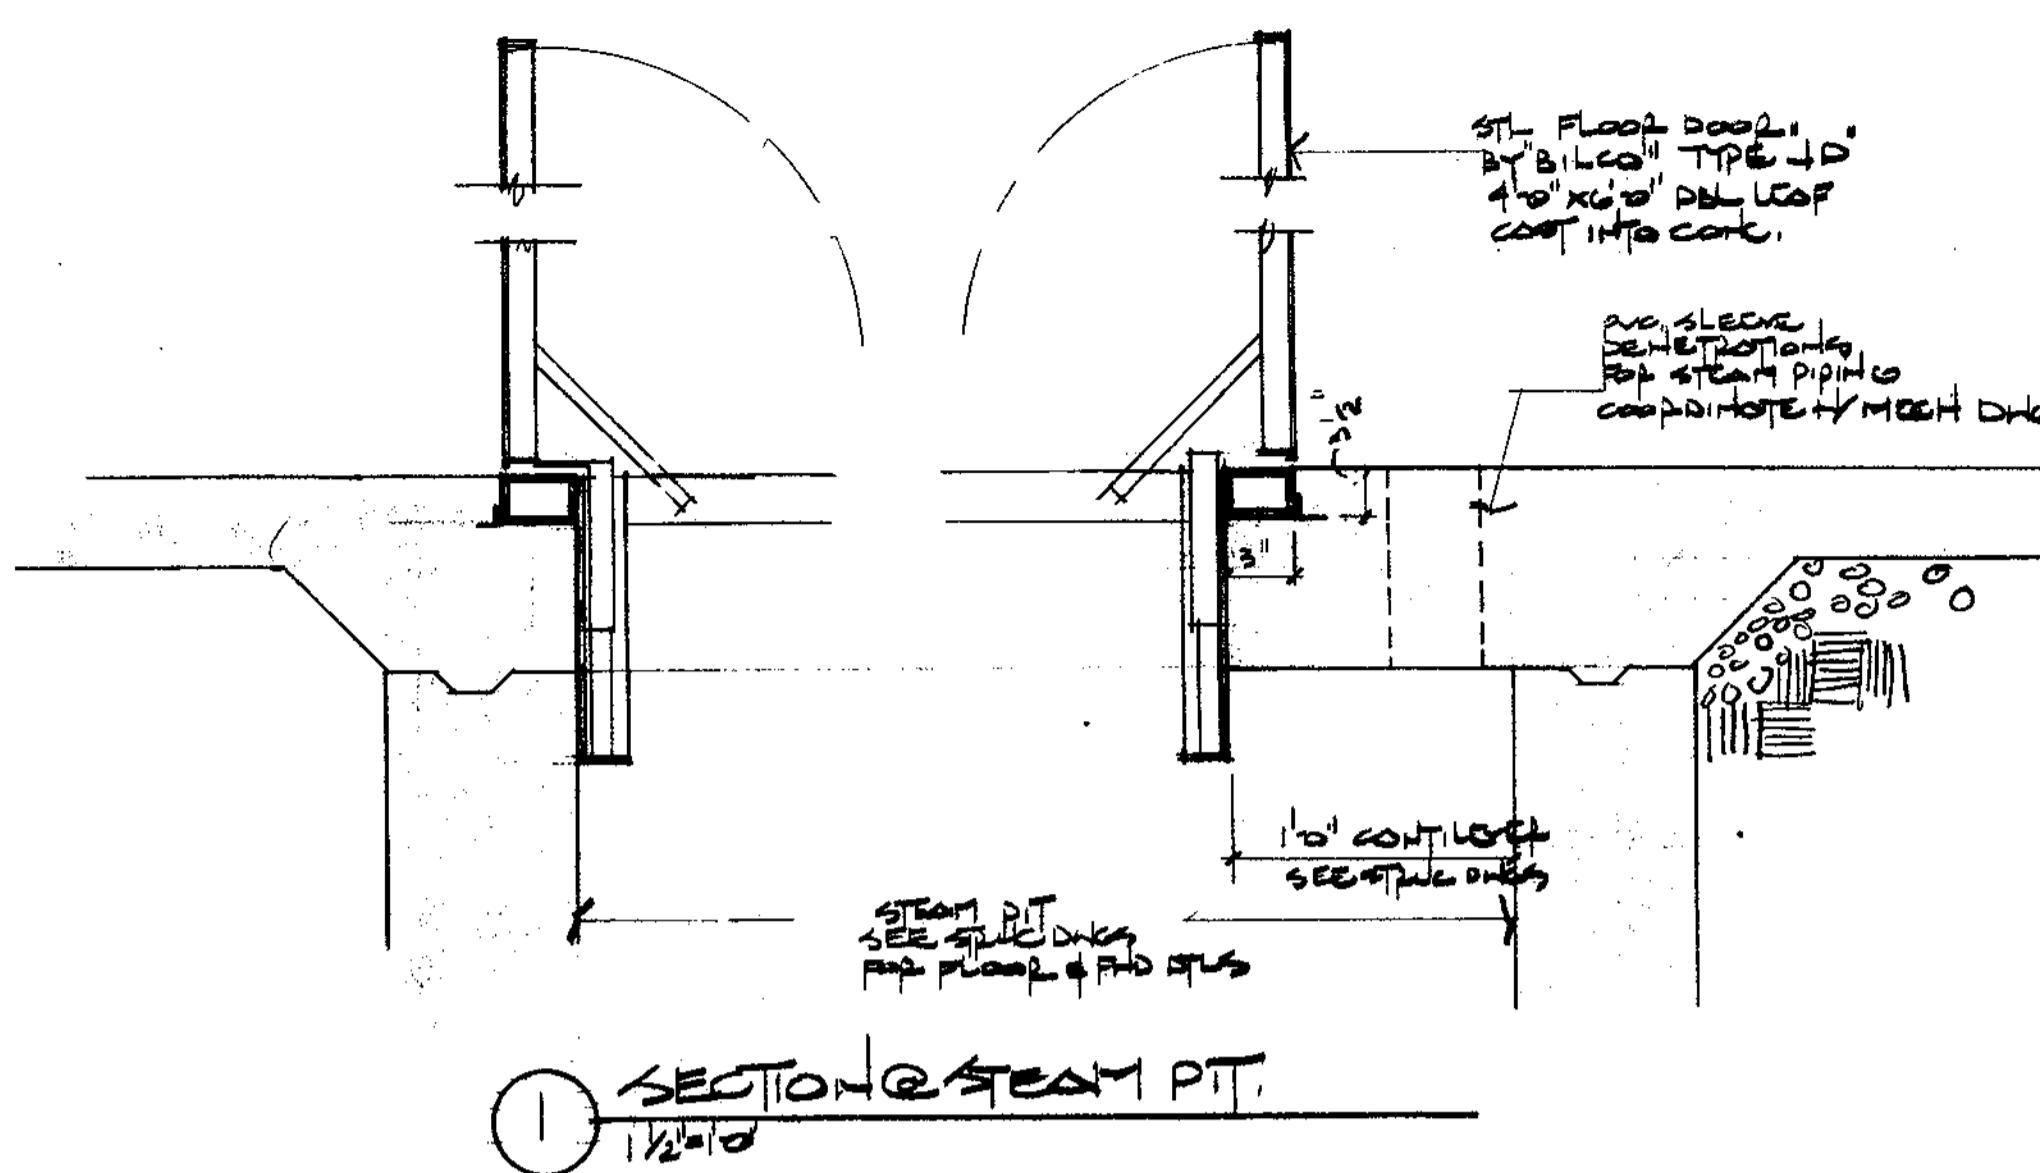

SECTION E

1/8" = 1'-0"

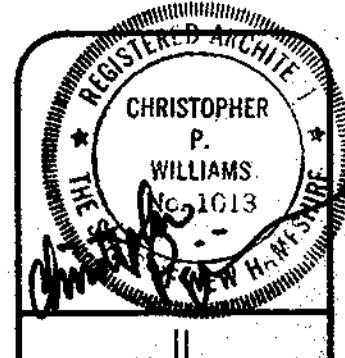

Christopher P. Williams, Architects

03233

03-278-6513

Copyright 1992

C.P. Williams

All Rights Reserved

**THORNE-SAGENDORPH
ART GALLERY**


Keene State College
Keene, New Hampshire

BUILDING SECTIONS

DATE 1 SEPTEMBER 1992
SCALE AS SHOWN
DRN BY RWH
PROJ. NO. 003


A7

003AS

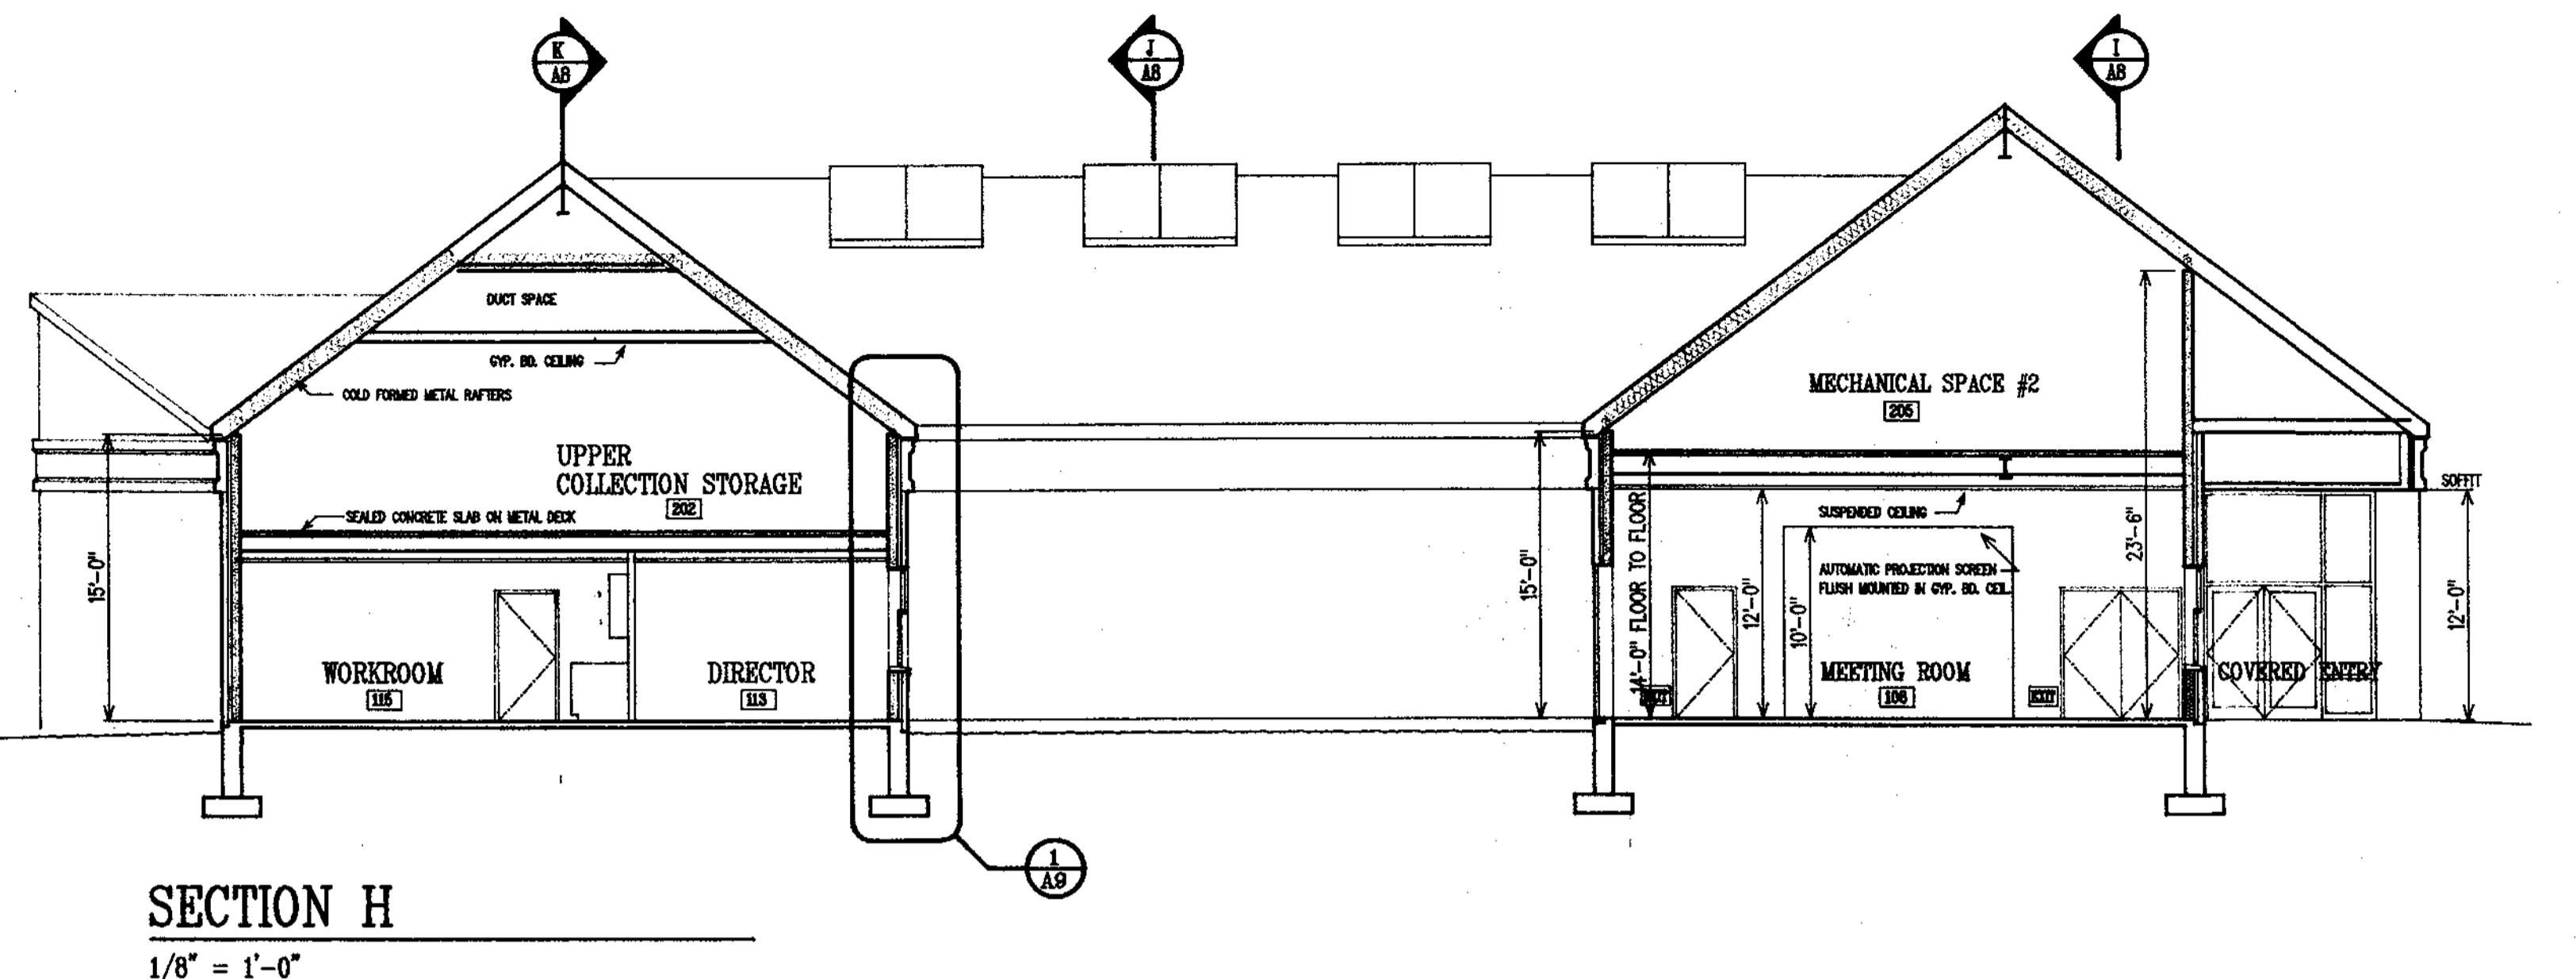


SECTION H

1/8" = 1'-0"

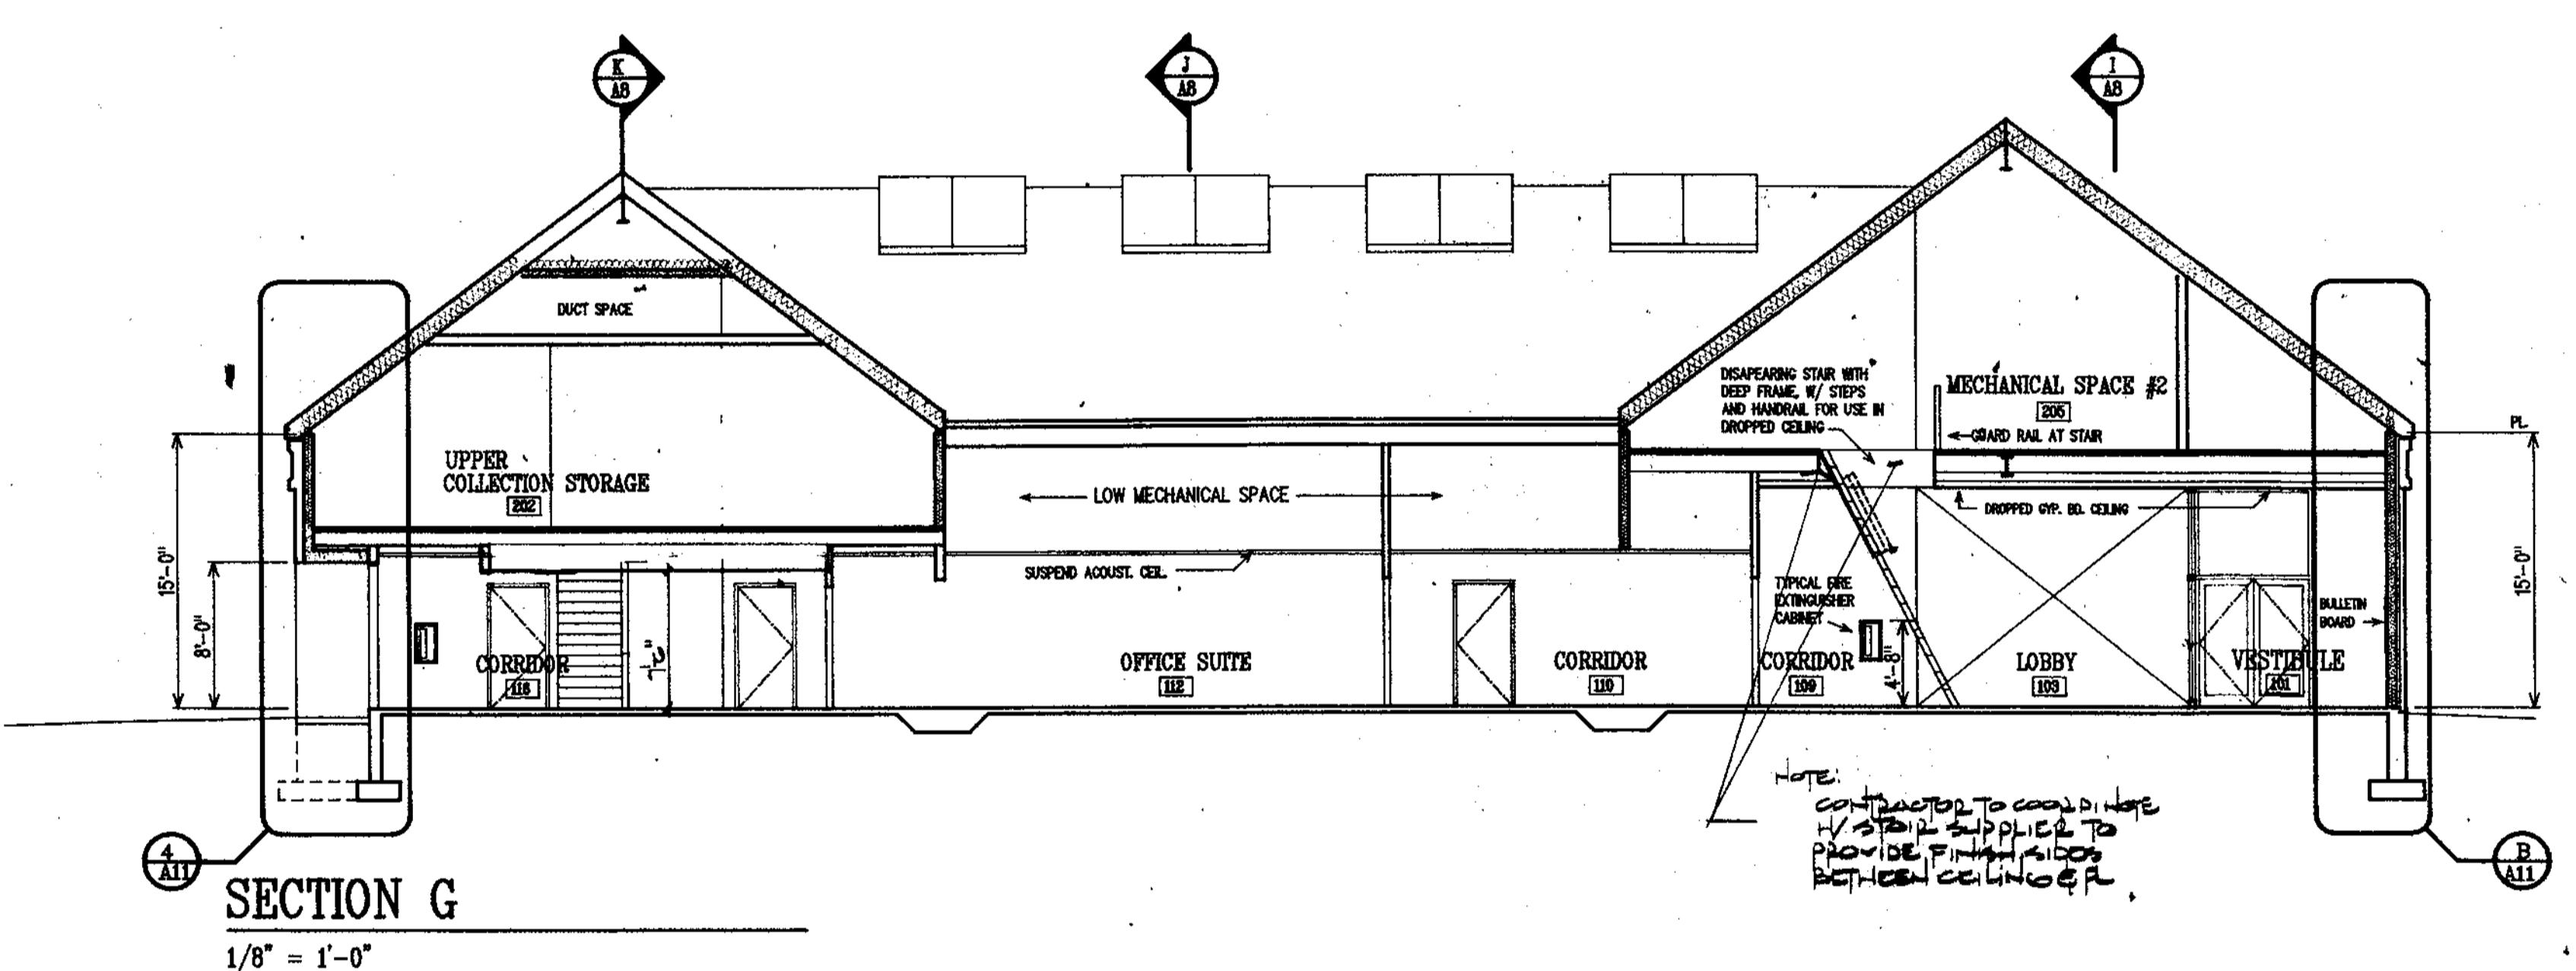









SECTION G

1/8" = 1'-0"

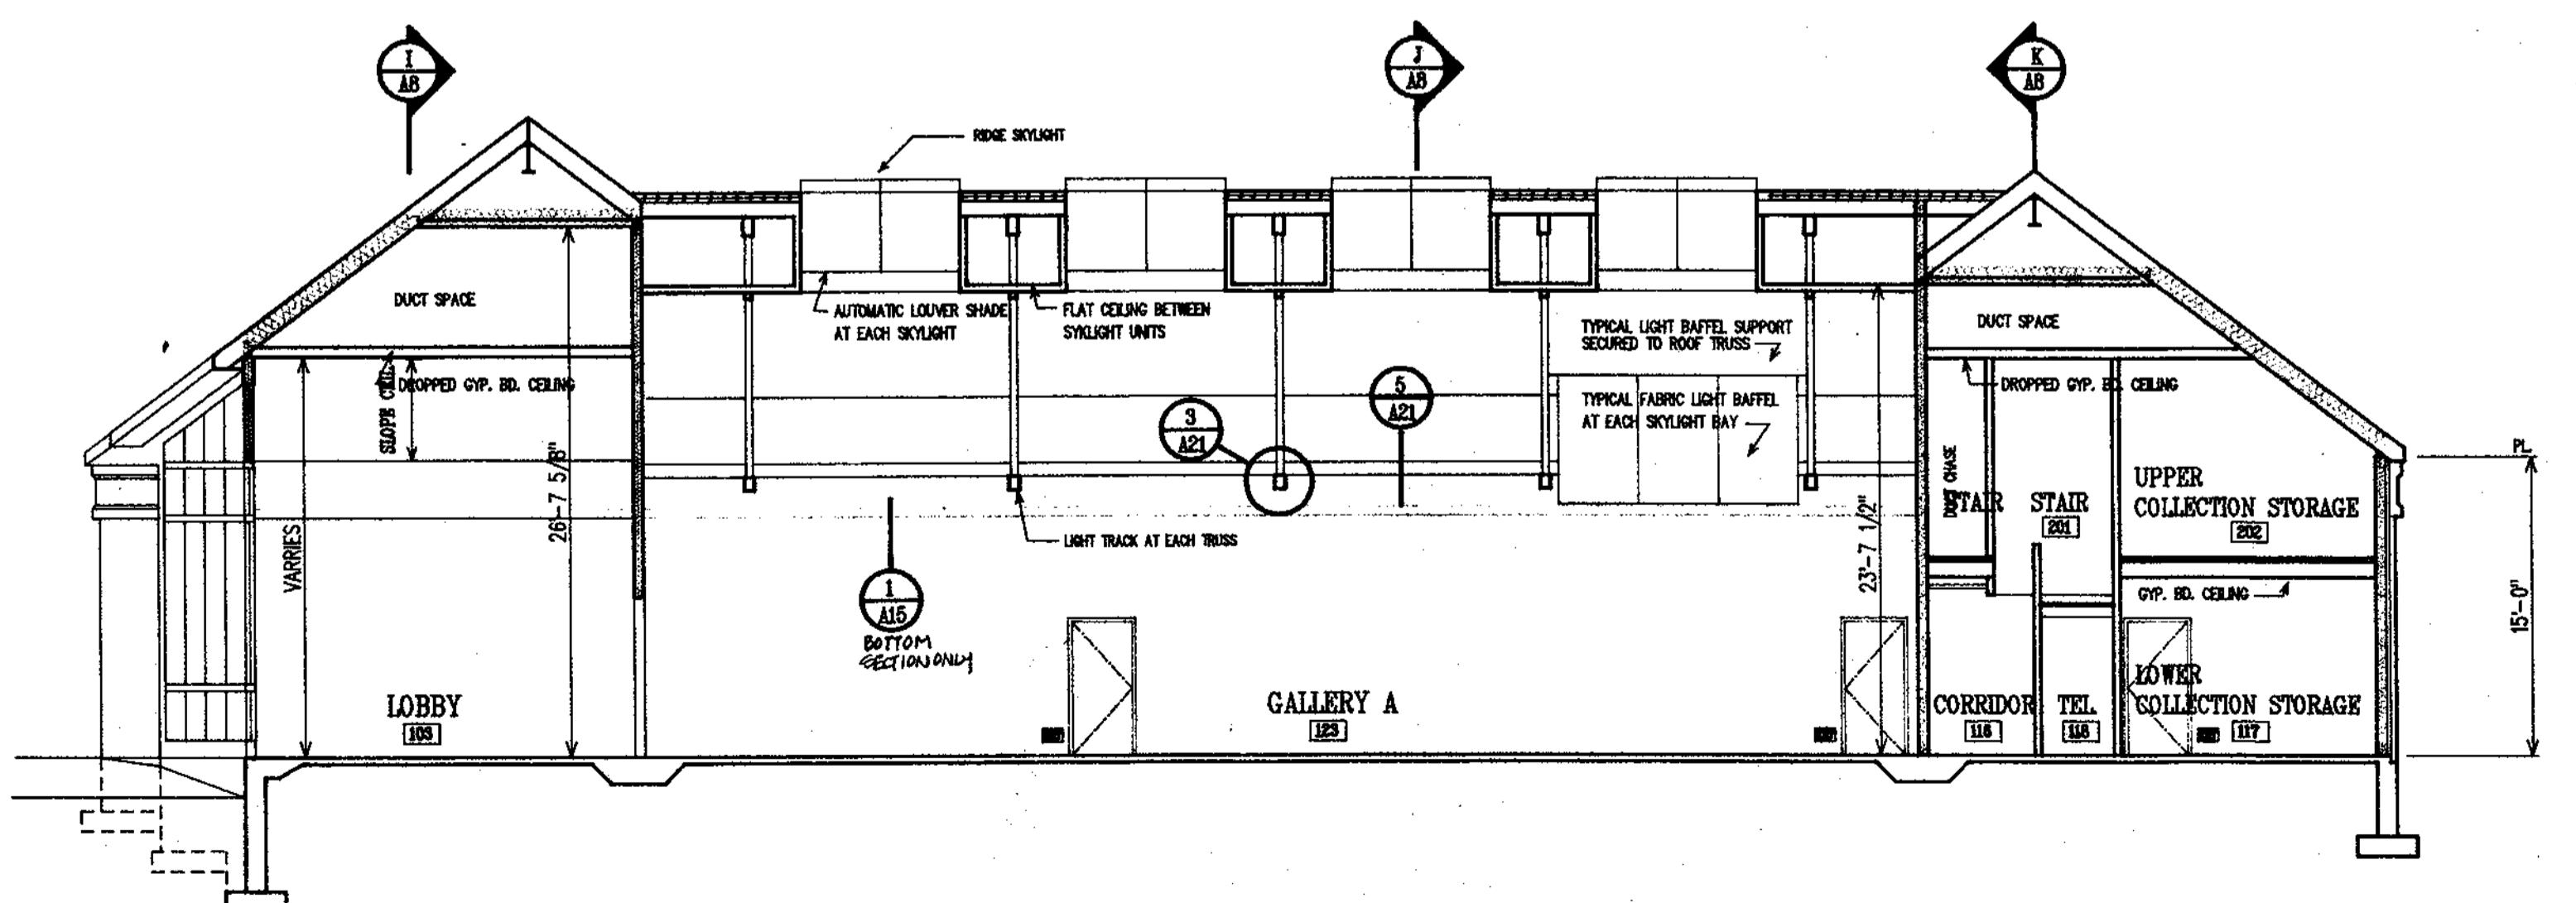

SECTION F

   1/8" = 1'-0"

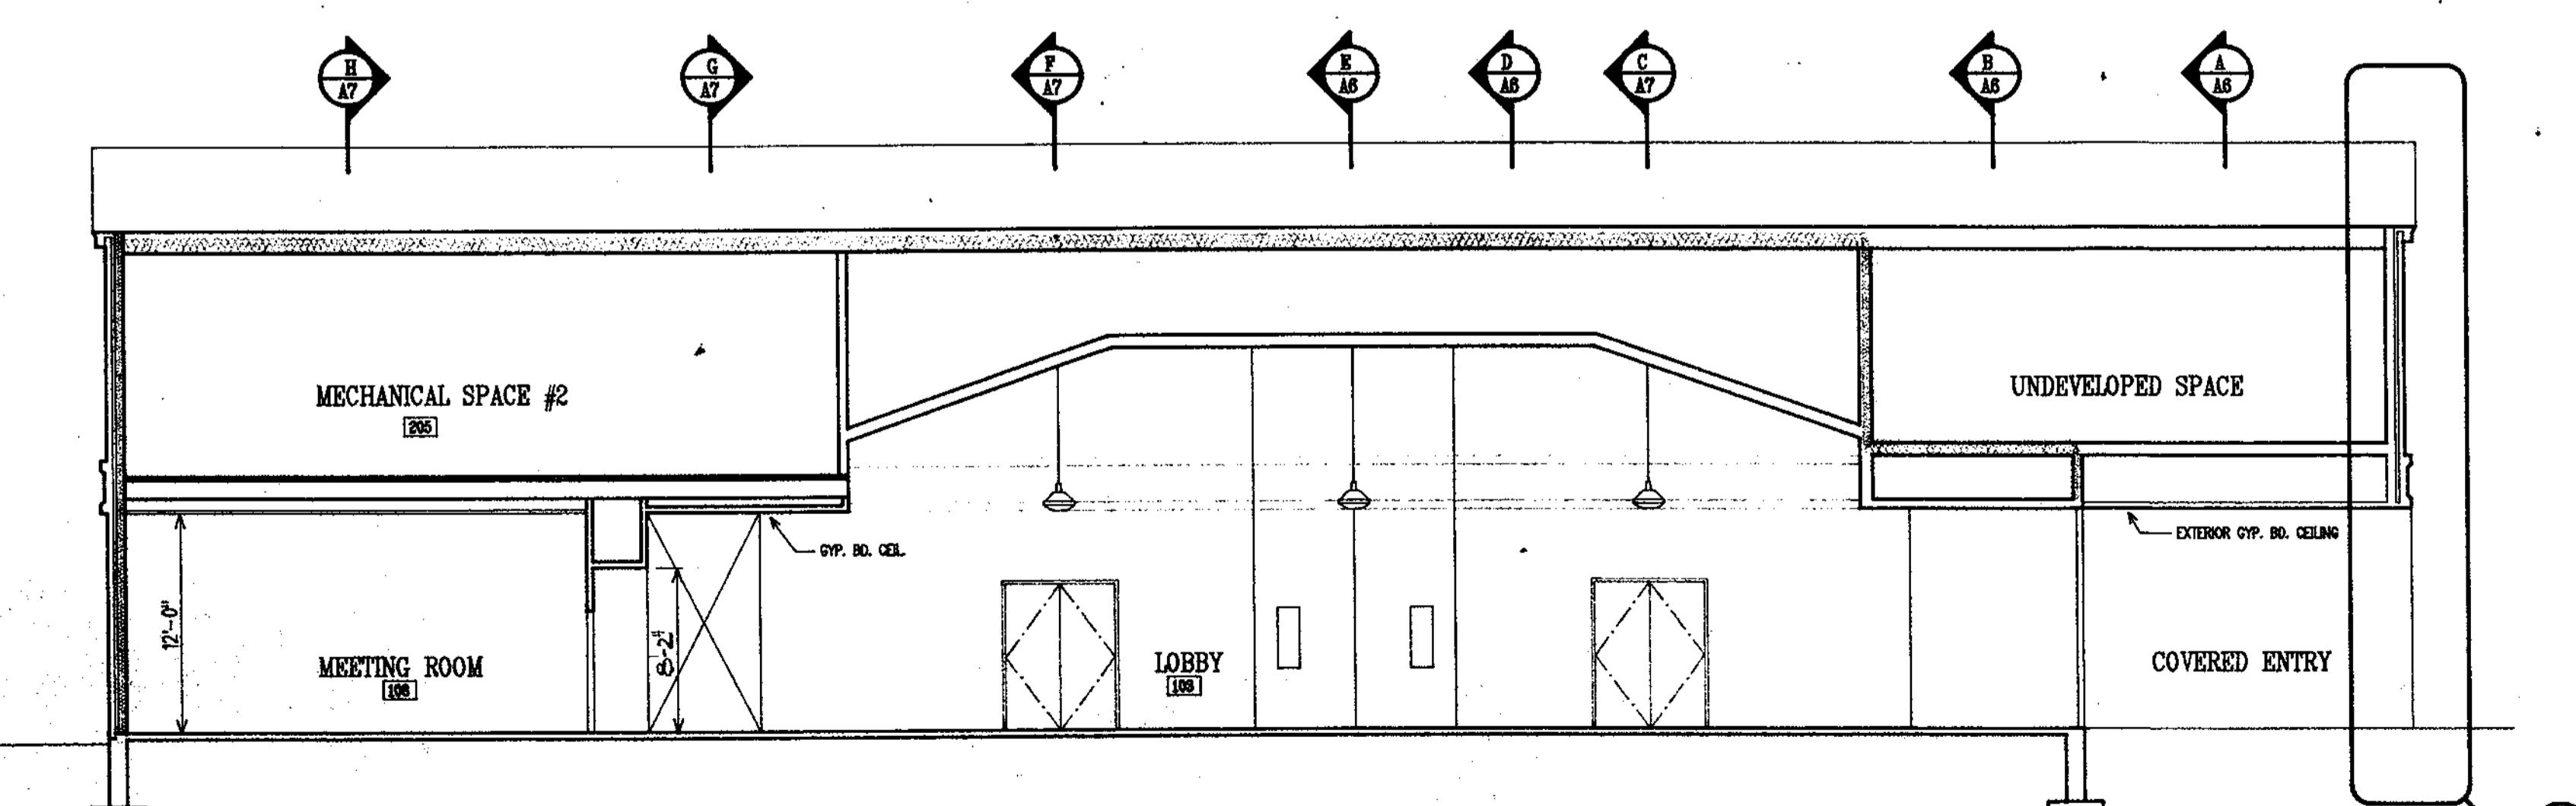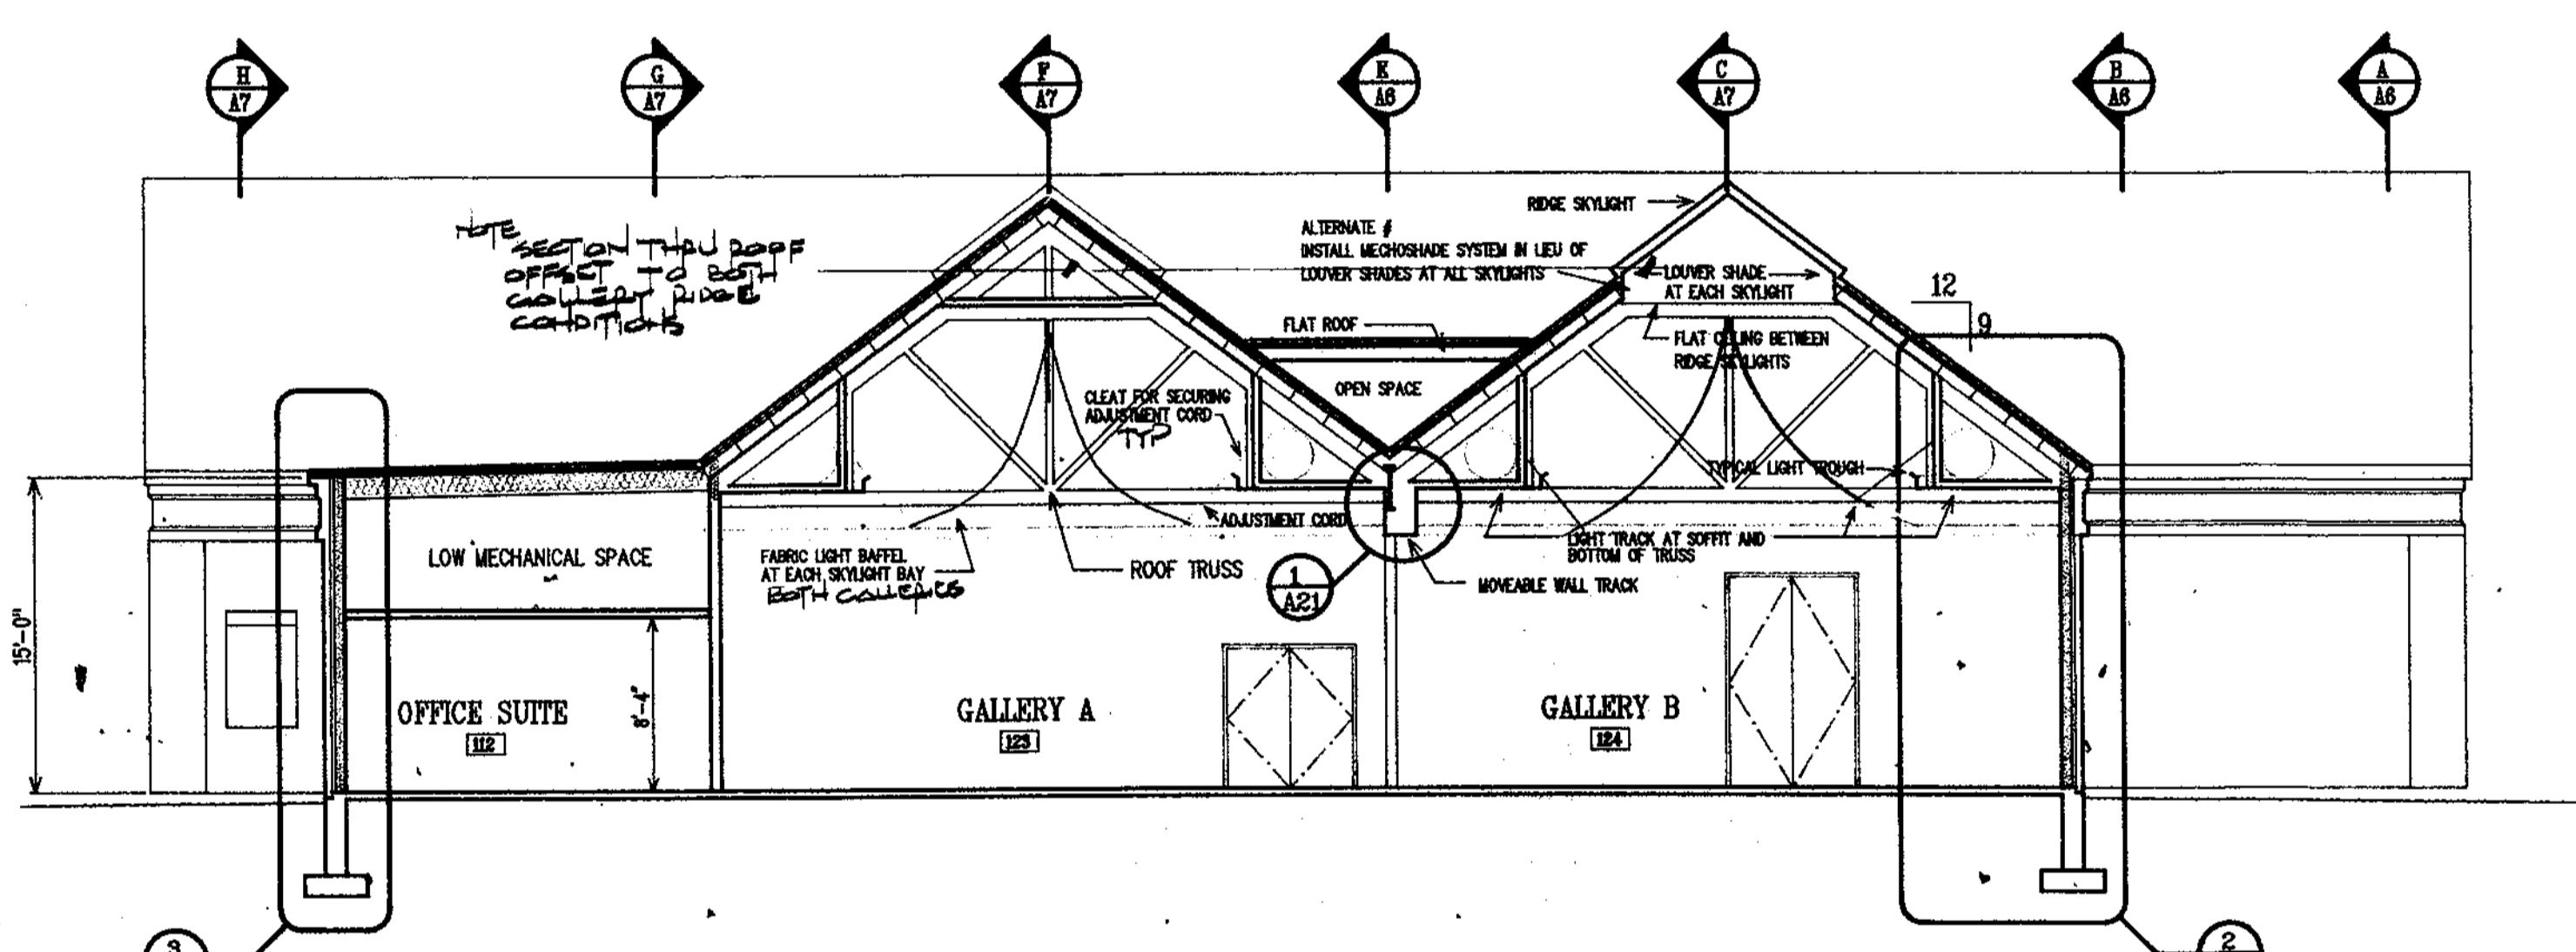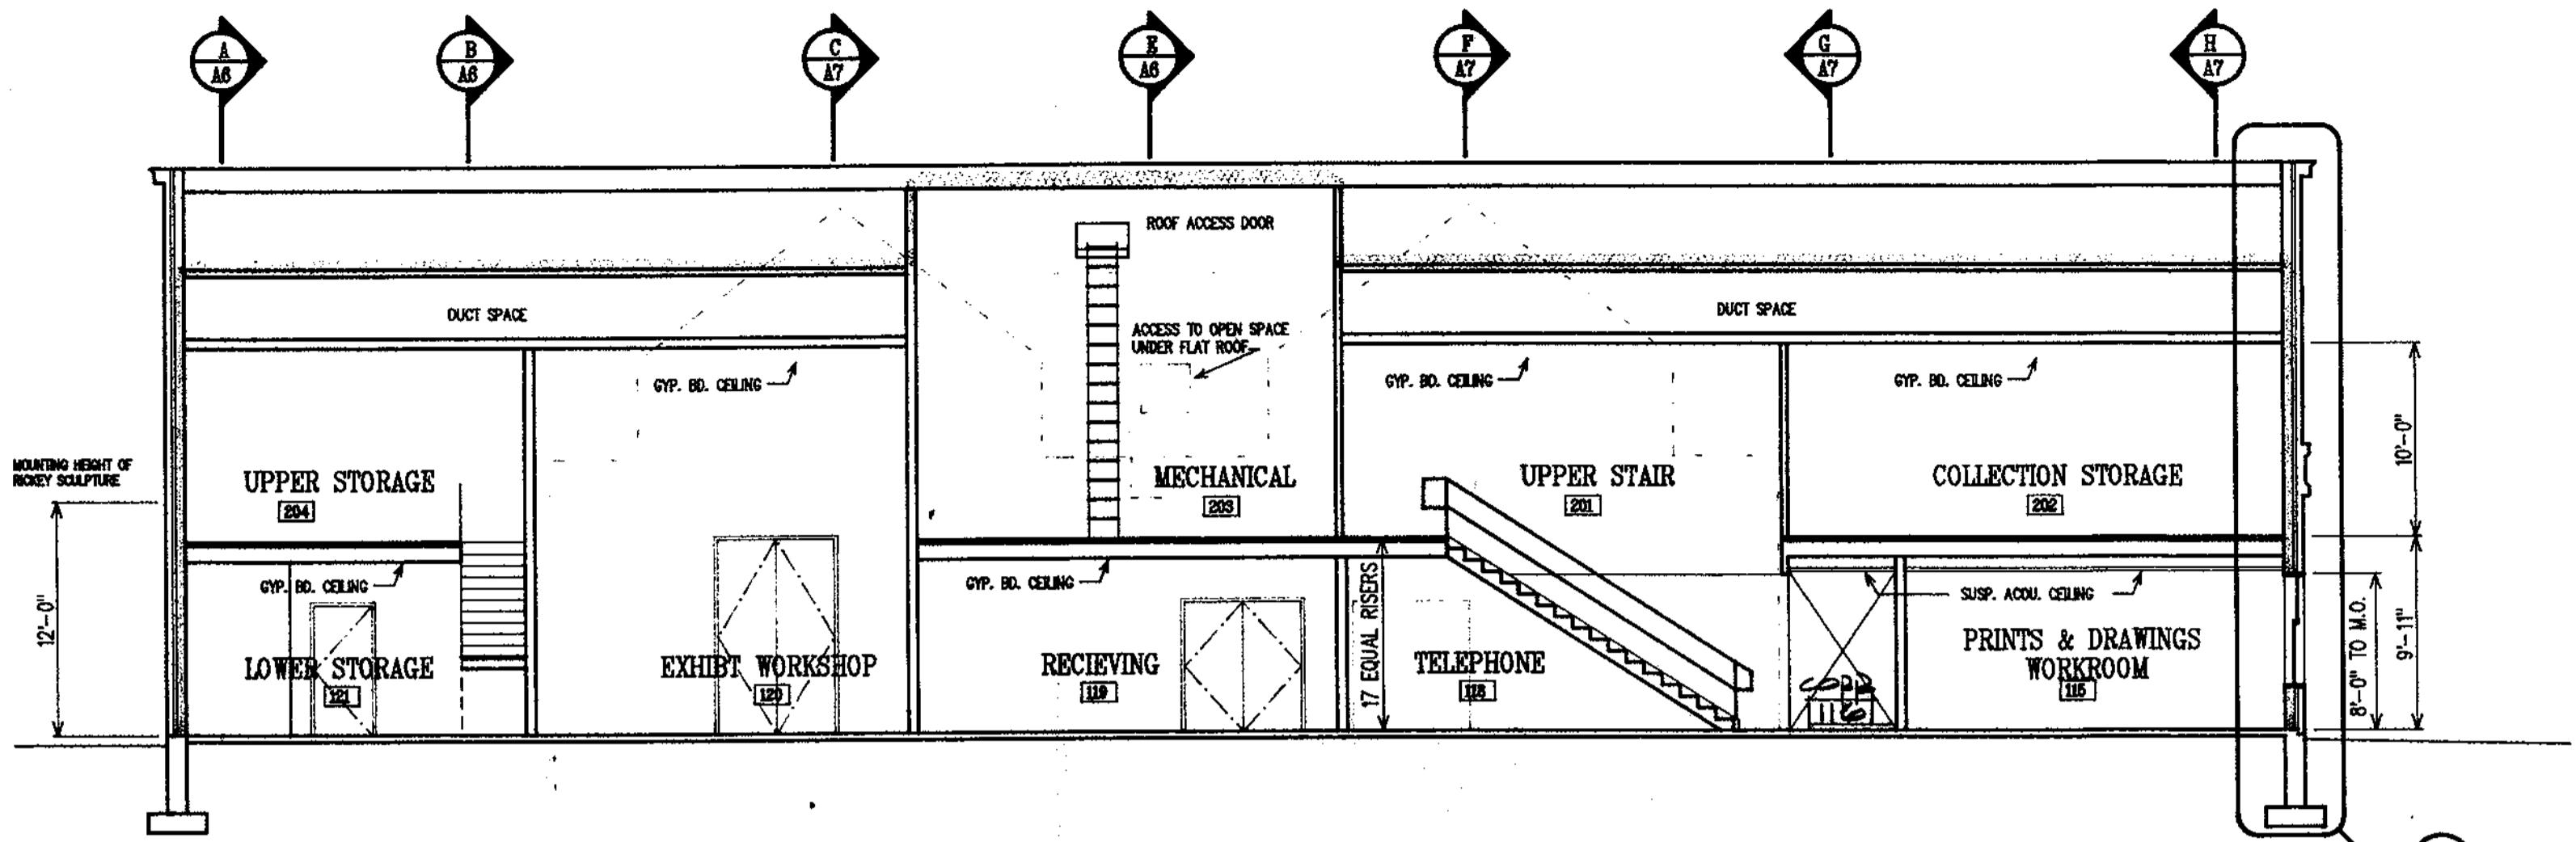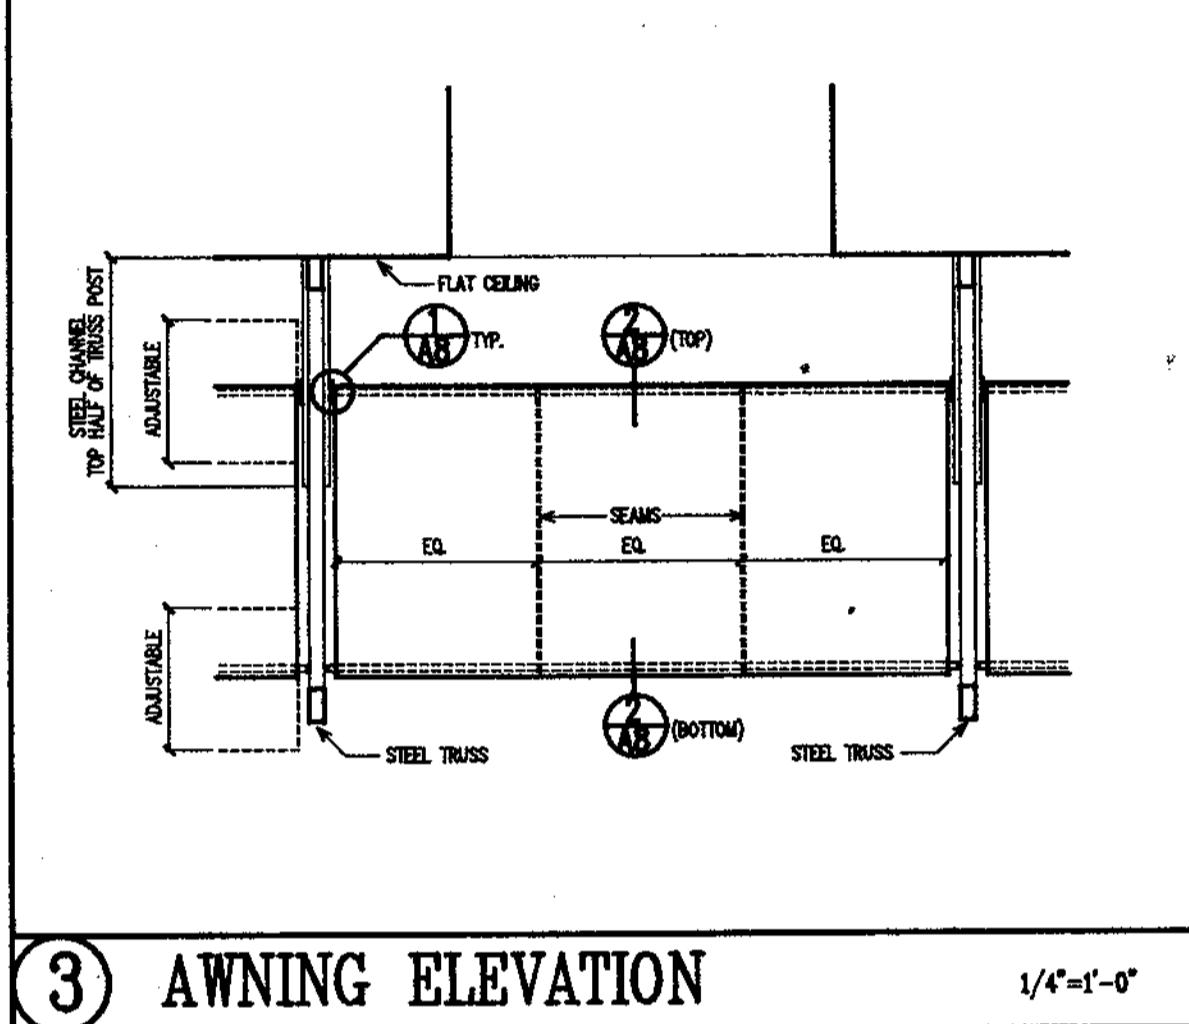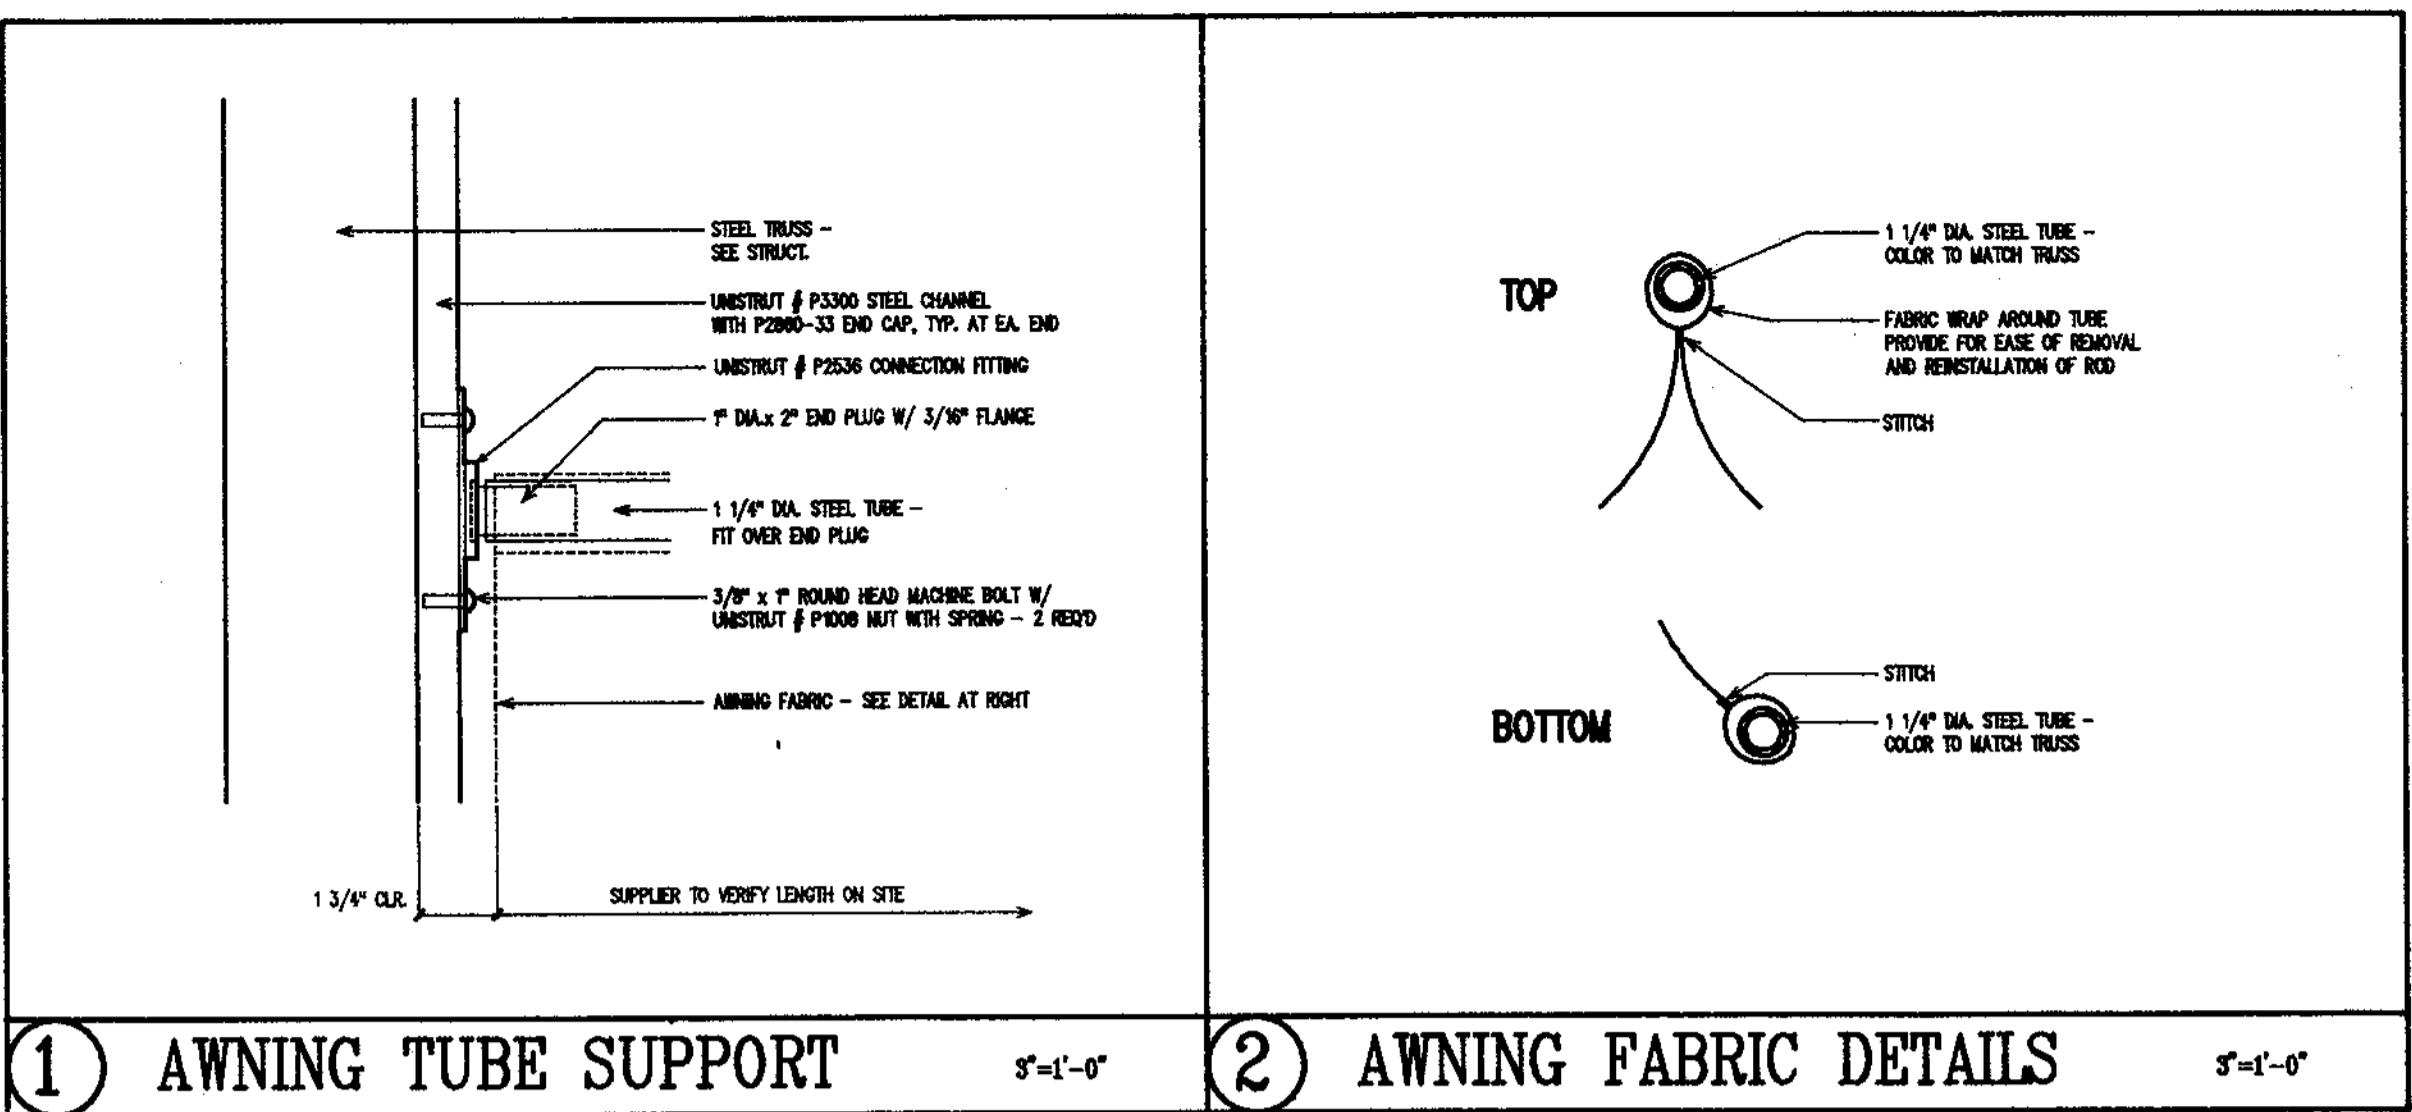

Copyright 1992
P. Williams
All Rights Reserved

**THORNE-SAGENDORPH
ART GALLERY**

BUILDING SECTIONS

DATE:	1 SEPTEMBER 1992
SCALE:	AS SHOWN
DRAWN BY:	RCH
PROJ. NO.:	C03

A8

003A5

